

The following changes to the tender documents are effective immediately and will form part of the contract documents:

Questions and Answers

Q1. Will it be required to provide an office for the Departmental Representative?

A1. A site trailer will be required at each site for use by PWGSC, CBSA, and Associated Engineering. This can be the same trailer used by the contractors.

Q2. Clarification is required regarding the propane tanks, as they are rentals and we will not be able to make the arrangements to relocate them as this request has to come from the owner. Also, for the requested new tanks for the generators, is the intent that the tanks be purchased as part of the contract, or are the new tanks to be rented? Additionally, are the new tanks, whether rented or purchased, to be filled as part of the contract, or will the owner provide the new fuel?

A2. The application and coordination of propane tank relocations and/or purchase and filling will be completed by CBSA, PWGSC and Associated Engineering.

Q3. Given there is no information currently available on the proposed fire alarm systems, will the connection be handled via Change Order?

A3. Connection to the building fire alarm systems is to be handled by Change Order after contract award, once additional information becomes available.

Q4. In Addendum No. 2, there is reference to review the Corcan drawings for the location of all sleeve penetrations in the foundation wall, but these drawings have not been provided. Will they be provided?

A4. See the attached Corcan drawing. This is a typical representation, the exact locations for each site will be determined on the issue for construction drawings.

End of Questions and Answers

END OF ADDENDUM NO. 3


ALL UNDERGROUND BY GENERAL CONTRACTOR
 (includes but not limited to services/foundation/penetrations, etc.)



CORCAN CONSTRUCTION
 Frontenac Institution
 Kingston, Ontario

****INITIAL PENETRATIONS MAY CHANGE LOCATION IF
 POWER COMES IN FROM ANOTHER DIRECTION****

NOTES:

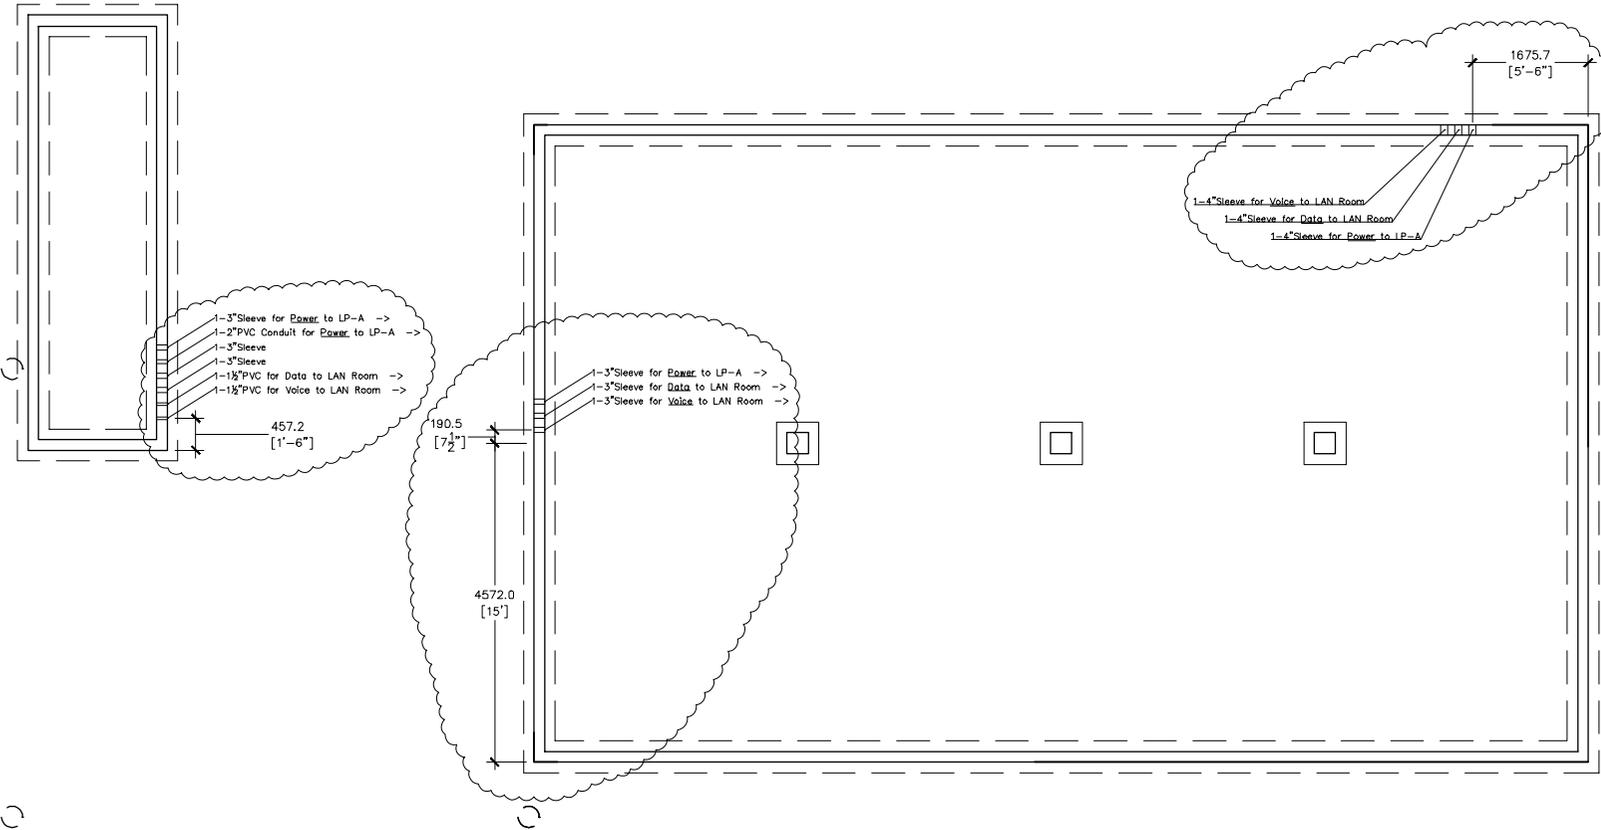

--	--

ENGINEER'S STAMP		
1 PRELIMINARY PLAN 31/08/12		
No.	DESCRIPTION	DATE

REVISION OR ISSUE

PROJECT TITLE / TITRE DU PROJET

CBSA
 Uniform Small Port of Er

DRAWING TITLE / TITRE DU DESSIN

Electrical Underground

DRAWN BY / DESSINE PAR

DMx

DESIGNED BY / CONC PAR

MB/RS

APPROVED BY / APPROUVE PAR

**

SCALE / ECHELLE

1:75

PROJECT DATE / DATE DU PROJET

**

PROJECT NUMBER / NOMBRE DU PROJET

32556

DRAWING NUMBER / NOMBRE DU DESSIN

E-8 of 8