



Association of Professional Engineers & Geoscientists of Saskatchewan
CERTIFICATE OF AUTHORIZATION
HDA ENGINEERING LTD.
Number 0281
Permission to Consult held by:
Discipline: Mech. No. 6093 Signature: J. Downes

DO NOT SCALE DRAWINGS

Revision/Revision	Description/Description	Date/Date
0	ISSUED FOR TENDER	2014-01-17

Project Title/Titre du projet

**SHARED LEARNING FACILITY
REGINA, SK**

Approved by/Approve par

Designed by/Concept par
TKC

Drawn by/Dessiné par
TKC/JJB

Project Manager/Administrateur de Projets
AC

Architectural and Engineering Resources Manager/
Ressources Architectural et de Directeur d'Ingénierie


Client/client

Drawing Title/Titre du dessin

**FOURTH FLOOR PLAN
MECHANICAL DEMOLITION**

Project No./No. du projet Sheet/feuille Revision no./La Révision no.

05/2013 M2-2 0

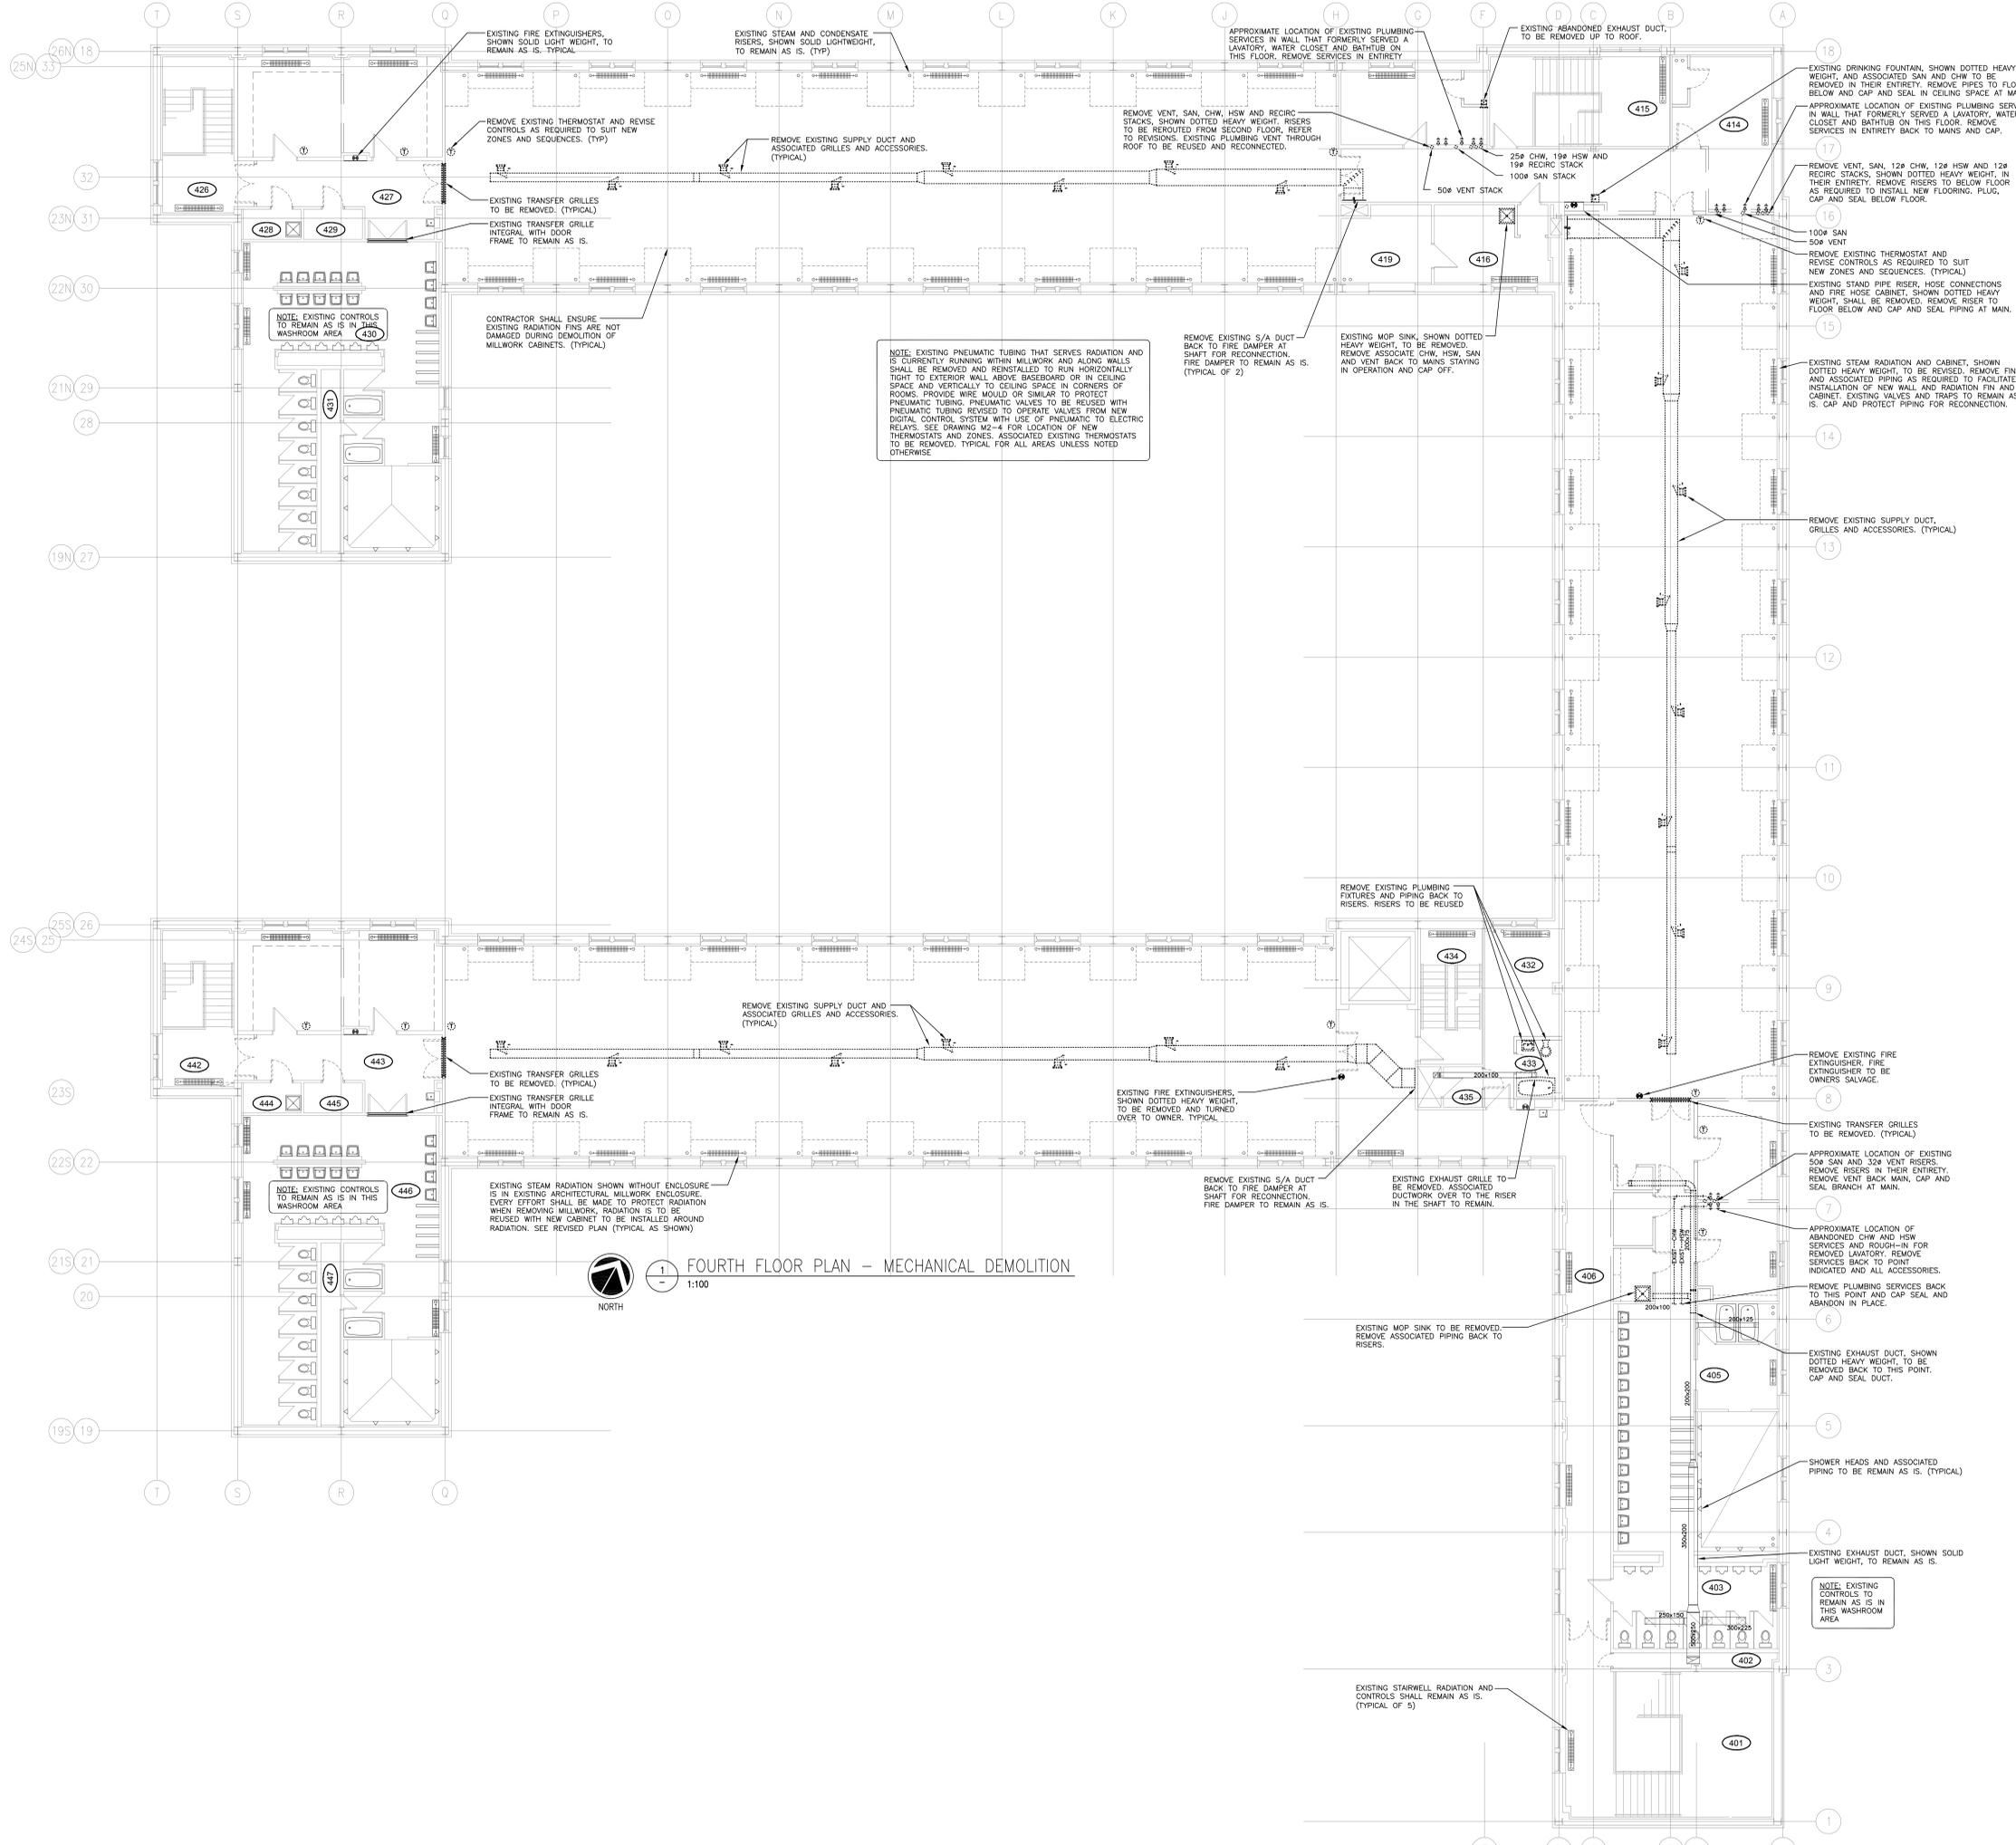

NOTE: EXISTING PNEUMATIC TUBING THAT SERVES RADIATION AND IS CURRENTLY RUNNING WITHIN MILLWORK AND ALONG WALLS SHALL BE REMOVED AND REINSTALLED TO RUN HORIZONTALLY TIGHT TO EXTERIOR WALL ABOVE BASEBOARD OR IN CEILING SPACE AND VERTICALLY TO CEILING SPACE IN CORNERS OF ROOMS. PROVIDE WIRE MOULD OR SIMILAR TO PROTECT PNEUMATIC TUBING. PNEUMATIC VALVES TO BE REUSED WITH PNEUMATIC TUBING REUSED TO OPERATE VALVES FROM NEW DIGITAL CONTROL SYSTEM WITH USE OF PNEUMATIC TO ELECTRIC RELAYS. SEE DRAWING M2-4 FOR LOCATION OF NEW THERMOSTATS AND ZONES. ASSOCIATED EXISTING THERMOSTATS TO BE REMOVED. TYPICAL FOR ALL AREAS UNLESS NOTED OTHERWISE.

CONTRACTOR SHALL ENSURE EXISTING RADIATION FINS ARE NOT DAMAGED DURING DEMOLITION OF MILLWORK CABINETS. (TYPICAL)

NOTE: EXISTING CONTROLS TO REMAIN AS IS IN THIS WASHROOM AREA

EXISTING STEAM RADIATION SHOWN WITHOUT ENCLOSURE IS IN EXISTING ARCHITECTURAL MILLWORK ENCLOSURE. EVERY EFFORT SHALL BE MADE TO PROTECT RADIATION WHEN REMOVING MILLWORK. RADIATION IS TO BE REUSED WITH NEW CABINET TO BE INSTALLED AROUND RADIATION. SEE REVISED PLAN (TYPICAL AS SHOWN)

FOURTH FLOOR PLAN - MECHANICAL DEMOLITION
1:100

