

stamp



**GENERAL NOTES**


- THIS DRAWING INDICATES GENERAL INTENT OF DESIGN ONLY. CONTRACTOR TO VERIFY SITE CONDITION BEFORE ORDERING MATERIALS AND COMMENCING WORK. REPORT TO ENGINEER ANY DISCREPANCIES BETWEEN EXISTING AND DESIGN DRAWINGS.
- PROVIDE NEW EQUIPMENT INCLUDING PIPING, VALVES, FITTINGS, FIXTURES, AND ACCESSORIES AS INDICATED.
- COORDINATE FINAL LOCATION OF FIXTURES NEW WORK WITH ALL TRADES.
- ALL PLUMBING FIXTURES SHALL BE VENTED AND ALL TRAPS SHALL BE PRIMMED AS PER ONTARIO PLUMBING CODE.
- CONTRACTOR TO SITE VERIFY EXISTING DOMESTIC WATER, VENT, & SANITARY SIZE & PIPE ROUTING.
- ALL PIPING SHALL BE INSULATED AS SPECIFIED IN THE SPECIFICATION.
- PLUMBING CONTRACTOR TO BE RESPONSIBLE FOR RUNNING FIXTURE VENTS TO BUILDING VENTS.
- PROVIDE NEW SPRINKLERS AS INDICATED. CONCEALED SPRINKLER HEAD CAP TO BE STAINLESS STEEL FINISH.
- SPRINKLERS TO BE INSTALLED IN ACCORDANCE WITH NFPA 13.
- CONTRACTOR TO PERFORM VIDEO SCOPING OF EXISTING SANITARY PIPING AND VERIFY PIPE INVERT ELEVATIONS, SIZE, AND ROUTING. SUBMIT FINDINGS TO ENGINEER IN SKETCH FORMAT FOR REVIEW.
- THE SPRINKLER CLASSIFICATION IS ORDINARY HAZARD GROUP II UNLESS OTHERWISE INDICATED.

**KEYNOTES**

- EXTEND PLUMBING SERVICES TO FUME HOOD SINK WITHIN THIS AREA. COORDINATE CONNECTION ON TOP OF UNIT C/W ISOLATION VALVES. CONTRACTOR TO TRENCH EXISTING SLAB ON GRADE FOR NEW SINK DRAIN CONNECTION. PATCH & REPAIR SLAB TO MATCH EXISTING. COORDINATE WITH ARCHITECTURAL.
- RPZ TYPE BACK FLOW PREVENTOR SERVING FUME HOOD SINK
- RESERVED
- RESERVED
- EXTEND COMPRESSED AIR PIPE TO FUME HOOD. PROVIDE FINAL CONNECTION C/W ISOLATION VALVE.
- FUTURE COMPRESSED AIR CONNECTION
- CONTRACTOR TO VERIFY ROUTING OF THE COMPRESSED AIR LINE AND EXISTING CEILING CONDITIONS AND ACCESSIBILITY. NOTIFY TO ENGINEER FOR ANY INTERFERENCES PRIOR TO COMMENCING WORK.

**MECHANICAL PLUMBING SERVICE REQUIREMENTS**

| TAG            | DCW | DHW | SANITARY DRAIN | SANITARY VENT | REMARKS |
|----------------|-----|-----|----------------|---------------|---------|
| FUME HOOD SINK | 120 | 120 | 400            | 400           |         |

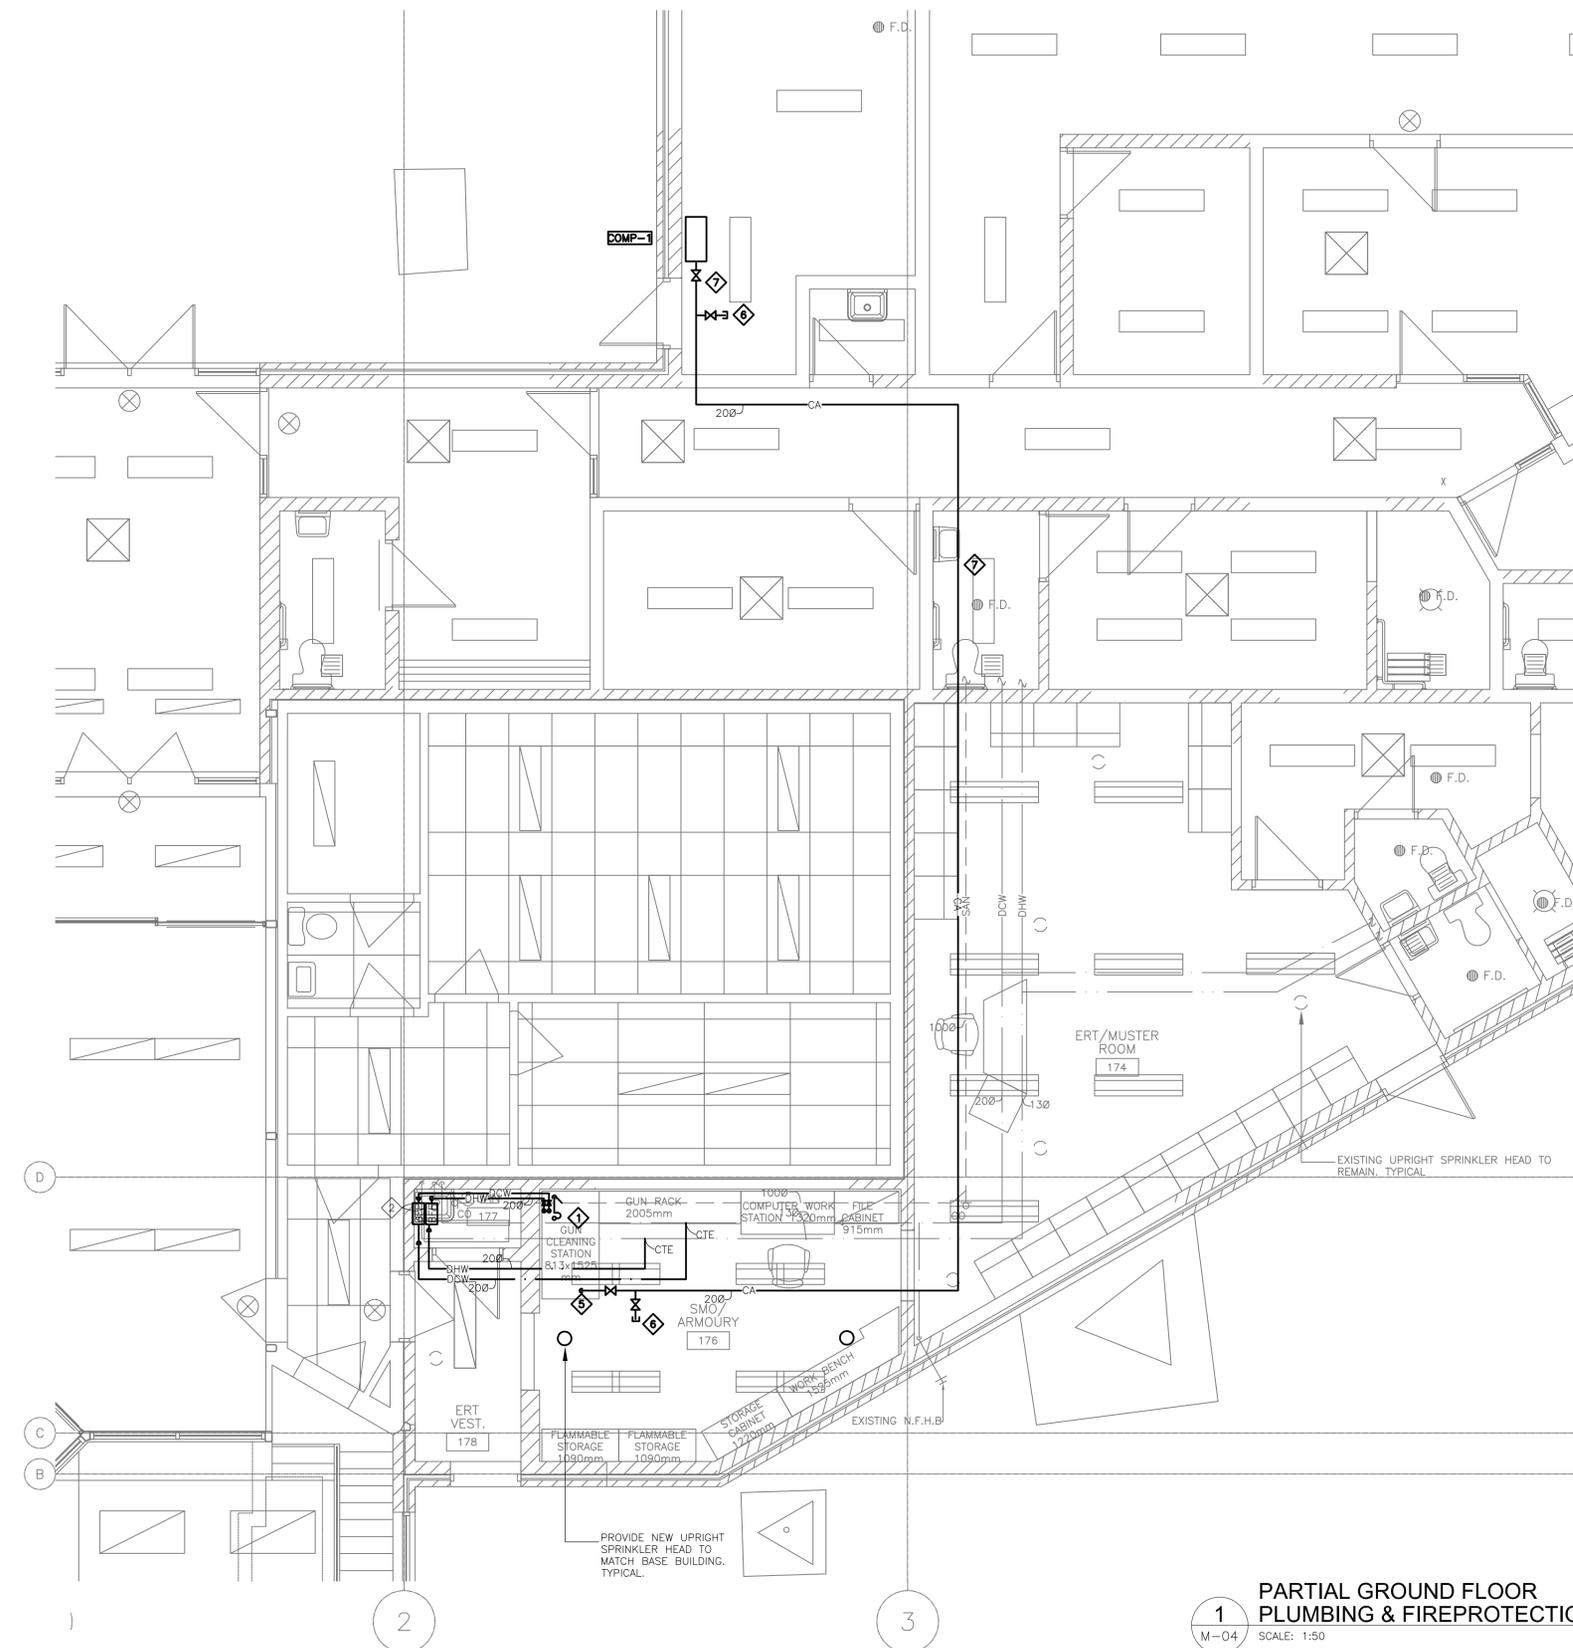

**1**  
PARTIAL GROUND FLOOR  
PLUMBING & FIREPROTECTION UPGRADE PLAN  
SCALE: 1:50  
0 500 1000 2000 3000

|          |       |            |
|----------|-------|------------|
| 1        | BID   | 2015-08-05 |
| revision | issue | date       |

Do not scale drawings. Verify all dimensions and conditions on site and immediately notify the Departmental Representative of all discrepancies.

|   |   |
|---|---|
| A | Detail No.<br>No. du détail   |
| B | drawing no. - where detail required<br>dessin no. - où détail exigé |
| C | drawing no. - where detailed<br>dessin no. - où détaillé            |

project title  
titre du projet  
**CAMPBELLFORD, ONTARIO  
WARKWORTH INSTITUTION BLDG WW27  
CORRECTIONAL SERVICES CANADA  
15847 County Road 29, KOL 1L0  
RETROFIT ARMOURY &  
SMO WORK AREA**

drawing title  
titre du dessin  
**PLUMBING & FIREPROTECTION  
UPGRADE PLAN**

drawn by  
dessiné par  
**M MOAZZAM**

designed by  
conçue par  
**H ABOUTALEBI**

approved by  
approuvée par  
**R DOMINGUEZ**

bid  
offre  
**K HAQUE** project manager  
administrateur de projets

project date  
date du projet  
**2015-06-15**

project no.  
no. du projet  
**R.069651.001**

drawing no.  
dessiné no.  
**M-04**