

ONSA F.C. O'Neil Solvén & Aasod's Limited
 Consulting Engineers
 3411 University Street, Suite 100, Vancouver, BC V6R 1A6
 604-271-1111


LICENSED PROFESSIONAL ENGINEER
 Province of New Brunswick
 L2841 R. Glen Rockett 2015
 R. Glen Rockett
 SEPT. 3, 2015
 INGENIEUR TITULAIRE DE PERMIS
 Province du Nouveau-Brunswick

revisions	description	date
7	ISSUED FOR TENDER	09/03/2015
6	ISSUED FOR TENDER	08/13/2015
5	ONSA 100% PEER REVIEW	07/24/2015
4	ISSUE FOR 100% REVIEW	06/30/2015
3	ISSUE FOR REVIEW	01/16/2015
2	ISSUE FOR REVIEW	01/06/2015
1	ISSUE FOR REVIEW	12/19/2014


project: GENERATOR REPLACEMENT DORCHESTER PENITENTIARY

drawing: ELECTRICAL PLANS

designed: RGR
 date: SEPTEMBER 3, 2015
 drawn: RJT
 date: SEPTEMBER 3, 2015
 approved: [Signature]
 date: [Signature]
 Tender: [Signature] Submission: 2015.09.10
 Project Manager: Administrateur de projets TPSOC
 project number: R.061866.001
 drawing no.: E-102

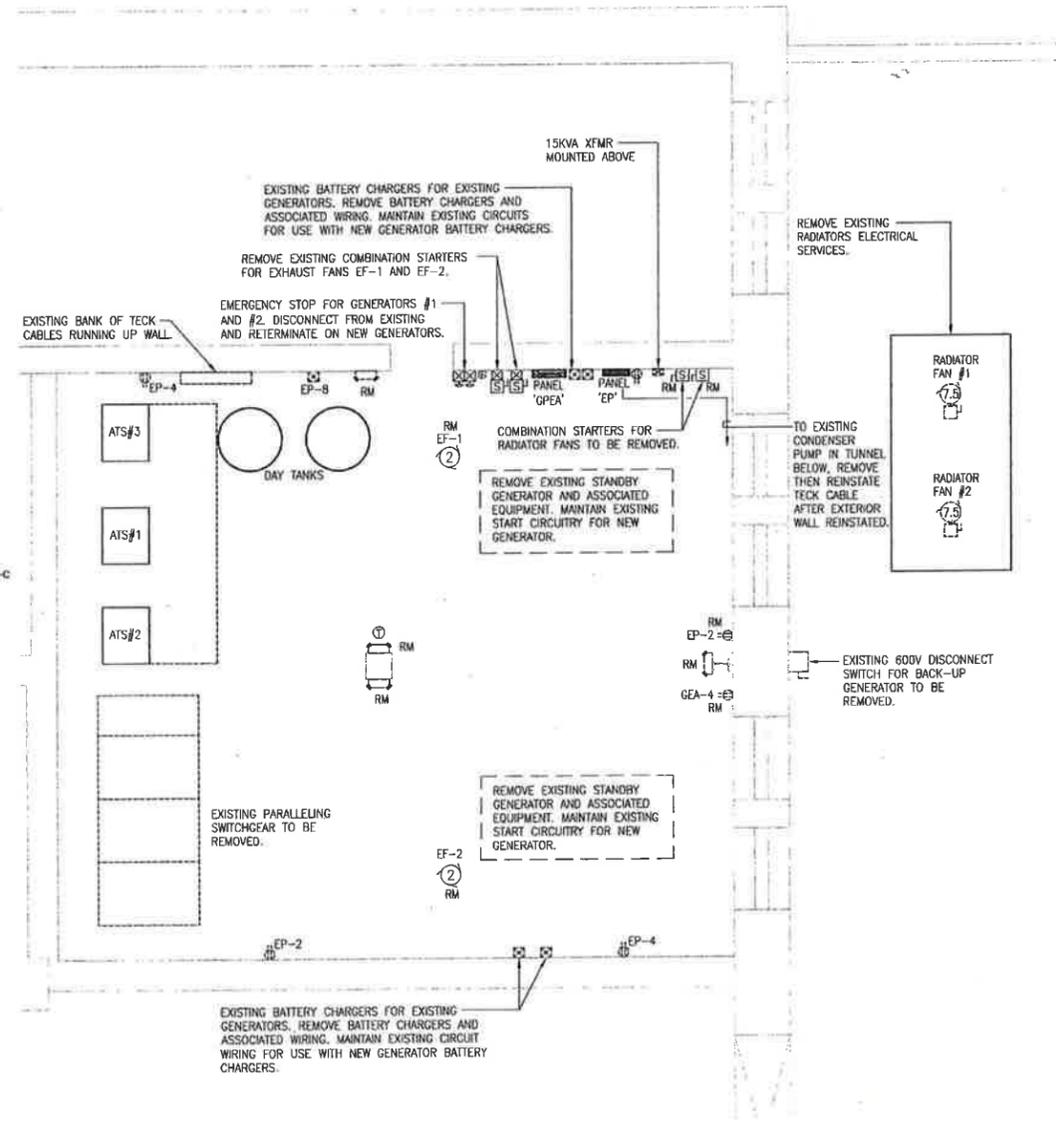

EXISTING GENERATOR ROOM LAYOUT
 SCALE: 1:50

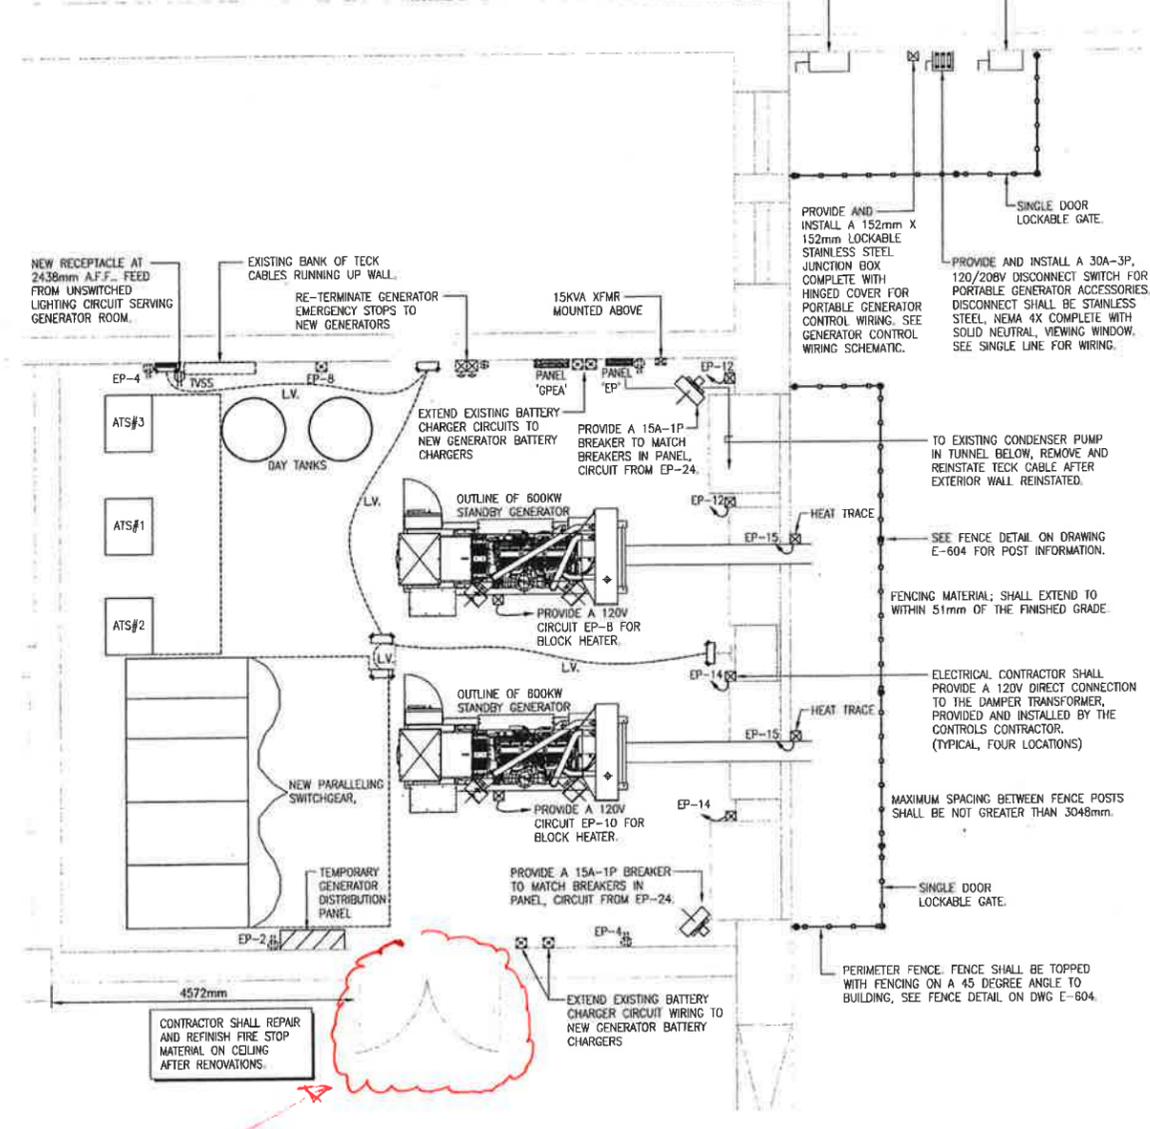

REVISED GENERATOR ROOM LAYOUT
 SCALE: 1:50

SEE DOOR DETAIL ON DRAWING E604