



**SITE PLAN** SCALE: 1:250

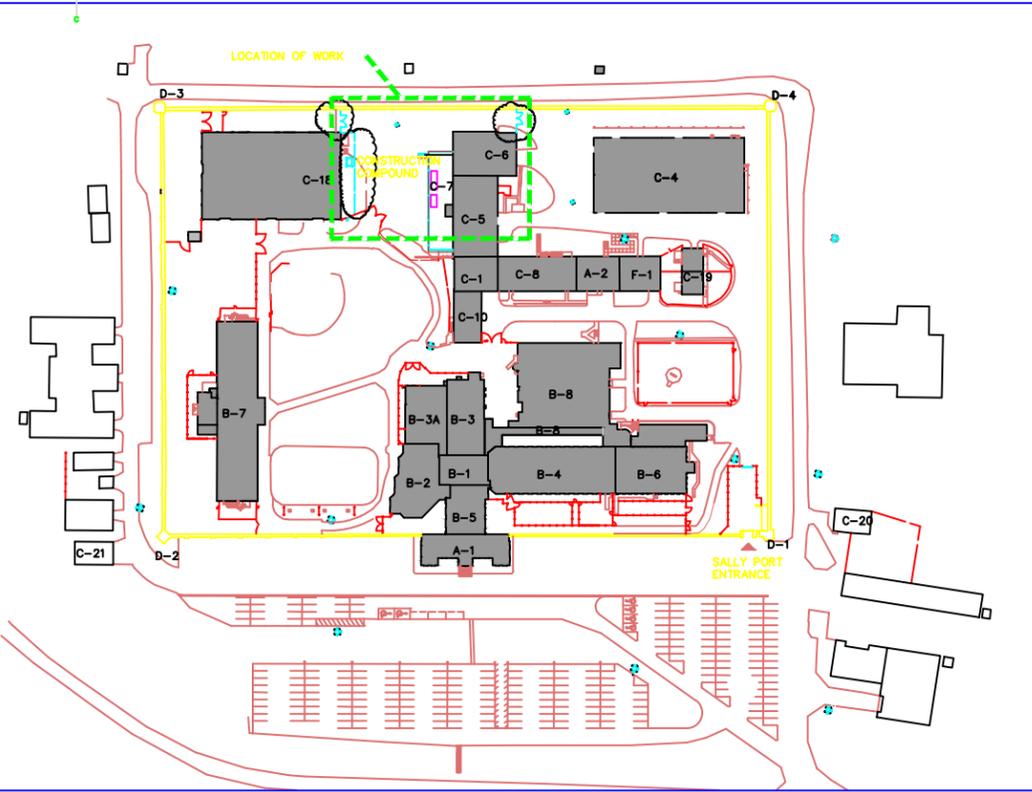


**LOCATION PLAN** SCALE: 1:1000

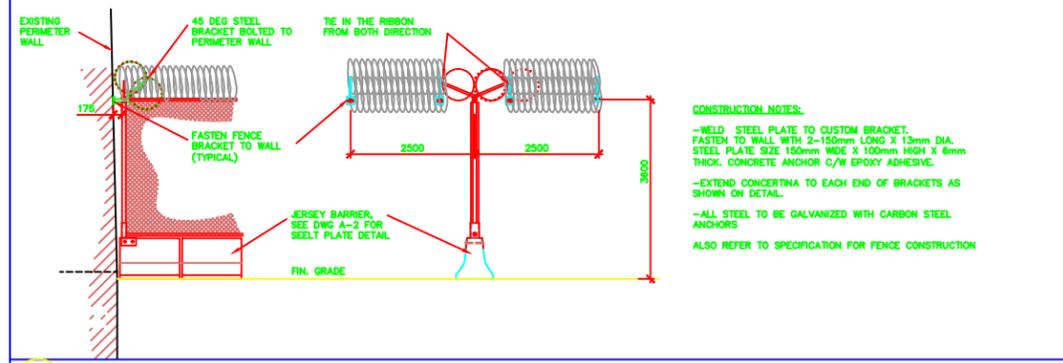

**CONCERTINA PERIMETER WALL DETAIL** SCALE: 1:50

DRAWING FOR REFERENCE PURPOSES ONLY

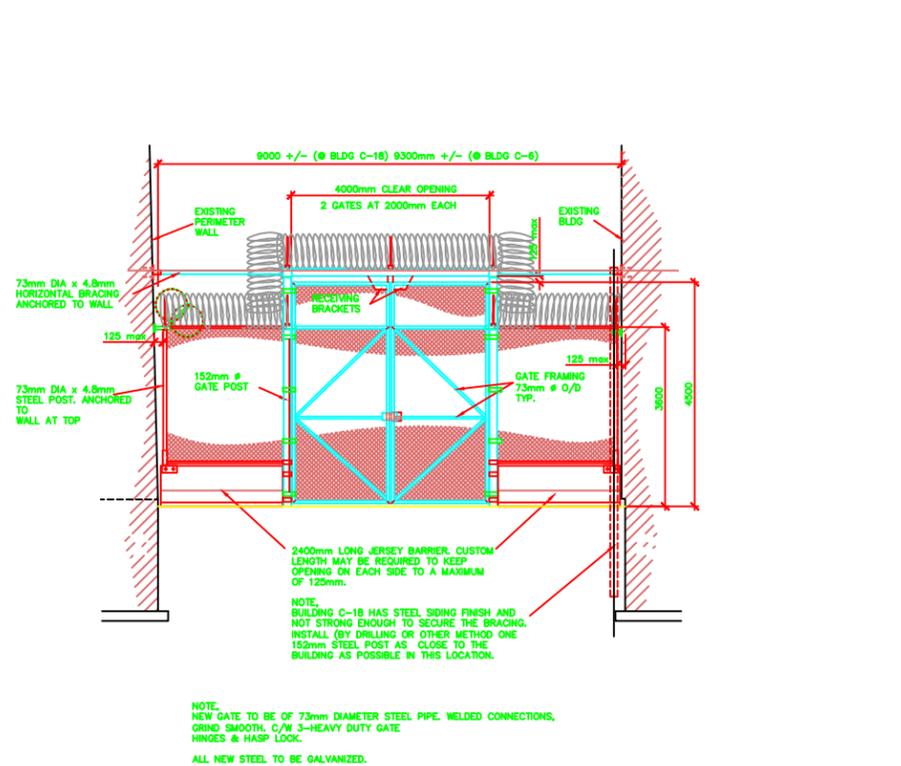

**VEHICLE GATE ELEVATION** SCALE: 1:50

1	INFORMATION	DEC 2015
revision		date
project	BUNKER C SYSTEM DECOMMISSIONING DORCHESTER PENITENTIARY MEDIUM DORCHESTER, NB	project
drawing	SITE & LOCATION PLAN FENCING REMOVAL DETAILS	drawing
designed	PWGC	comp
date	2014	date
drawn	M.DEGRACE	drawn
date	DEC 2015	date
approved		approved
date		date
Tender		Source/Info
PWGC		PWGC
Project Manager	Administrateur de projet	Project Manager
project number	R.061874.001	no. de projet
drawing no.	A-1	no. de dessin