





**NOTES:**

1. CONTRACTORS ARE REQUIRED TO THOROUGHLY FAMILIARIZE WITH EXISTING CONDITIONS AND THESE DOCUMENTS PRIOR TO BIDDING, AND PRIOR TO COMMENCING WORK. NO ALLOWANCE WILL BE MADE FOR FAILURE TO DO SO.
2. APPROXIMATE FIGURED AND SCALE DIMENSIONS OF EXISTING CONDITIONS ARE PROVIDED FOR GENERAL ORIENTATION ONLY, AND REQUIRE ONGOING VERIFICATION BY CONTRACTOR. DISCREPANCIES AFFECTING THE WORK SHALL BE REPORTED TO DEPARTMENTAL REPRESENTATIVE PRIOR TO PROCEEDING.
3. COMPLETE CORRECTIONS AND PATCHING OF ALL SUBSTRATES, AND ALLOW FOR INSPECTION, PRIOR TO INSTALLATION OF NEW FINISHES.
4. PROVIDE NEW WALL AND CEILING COATINGS AS PER DRAWINGS AND SPEC.
5. LOCATE NEW STAGE LIGHTING TRUSS (BY ELECTRICAL DIVISION) @ 914 CLEAR OF LOWEST STEP. TRUSS SHALL BE FABRICATED WITH 10.5M INSIDE LENGTH, 8.4M INSIDE RADIUS. PROVIDE UNOBTUSIVE ATTACHMENT DETAILS TO MAIN STRUCTURE, ENGINEER-STAMPED, FOR 200% OF WEIGHT OF ALL COMPONENTS PLUS 150 KG AT ANY POINT. PROTECT FACTORY FINISHES.
6. PROVIDE 2-PANEL BACKDROP TRAVELLING CURTAIN ON MANUAL TRACK AS SPECIFIED. SITE-BEND TRACK FOR SMOOTH CURVATURE FROM WALL AT ENDS, TO MINIMUM PROTRUSION TO CONCEAL EXISTING PROJECTION SCREEN, WITH LOADING AS PER SPEC. APPROX. RADIUS 49m (CHECK ON SITE)

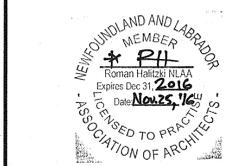

\* See note, sheet A.1

0	FOR TENDER	NOV. 25 2016
revisions		date
project	NORTHWEST ATLANTIC FISHERIES CENTRE ST. JOHN'S, NL AUDITORIUM UPGRADES	
drawing	NEW REFLECTED CEILING PLAN	
designed	conçu	
date		
drawn	dessiné	
date		
approved	approuvé	
date		
Tender	Submission	
Sandra K 2016-11-30	J.D.	
PWGSC Project Manager	Administrateur de projets TPSGC	
project number	no. du projet	
	R.081909.001	
drawing no.	no. du dessin	
	A4	

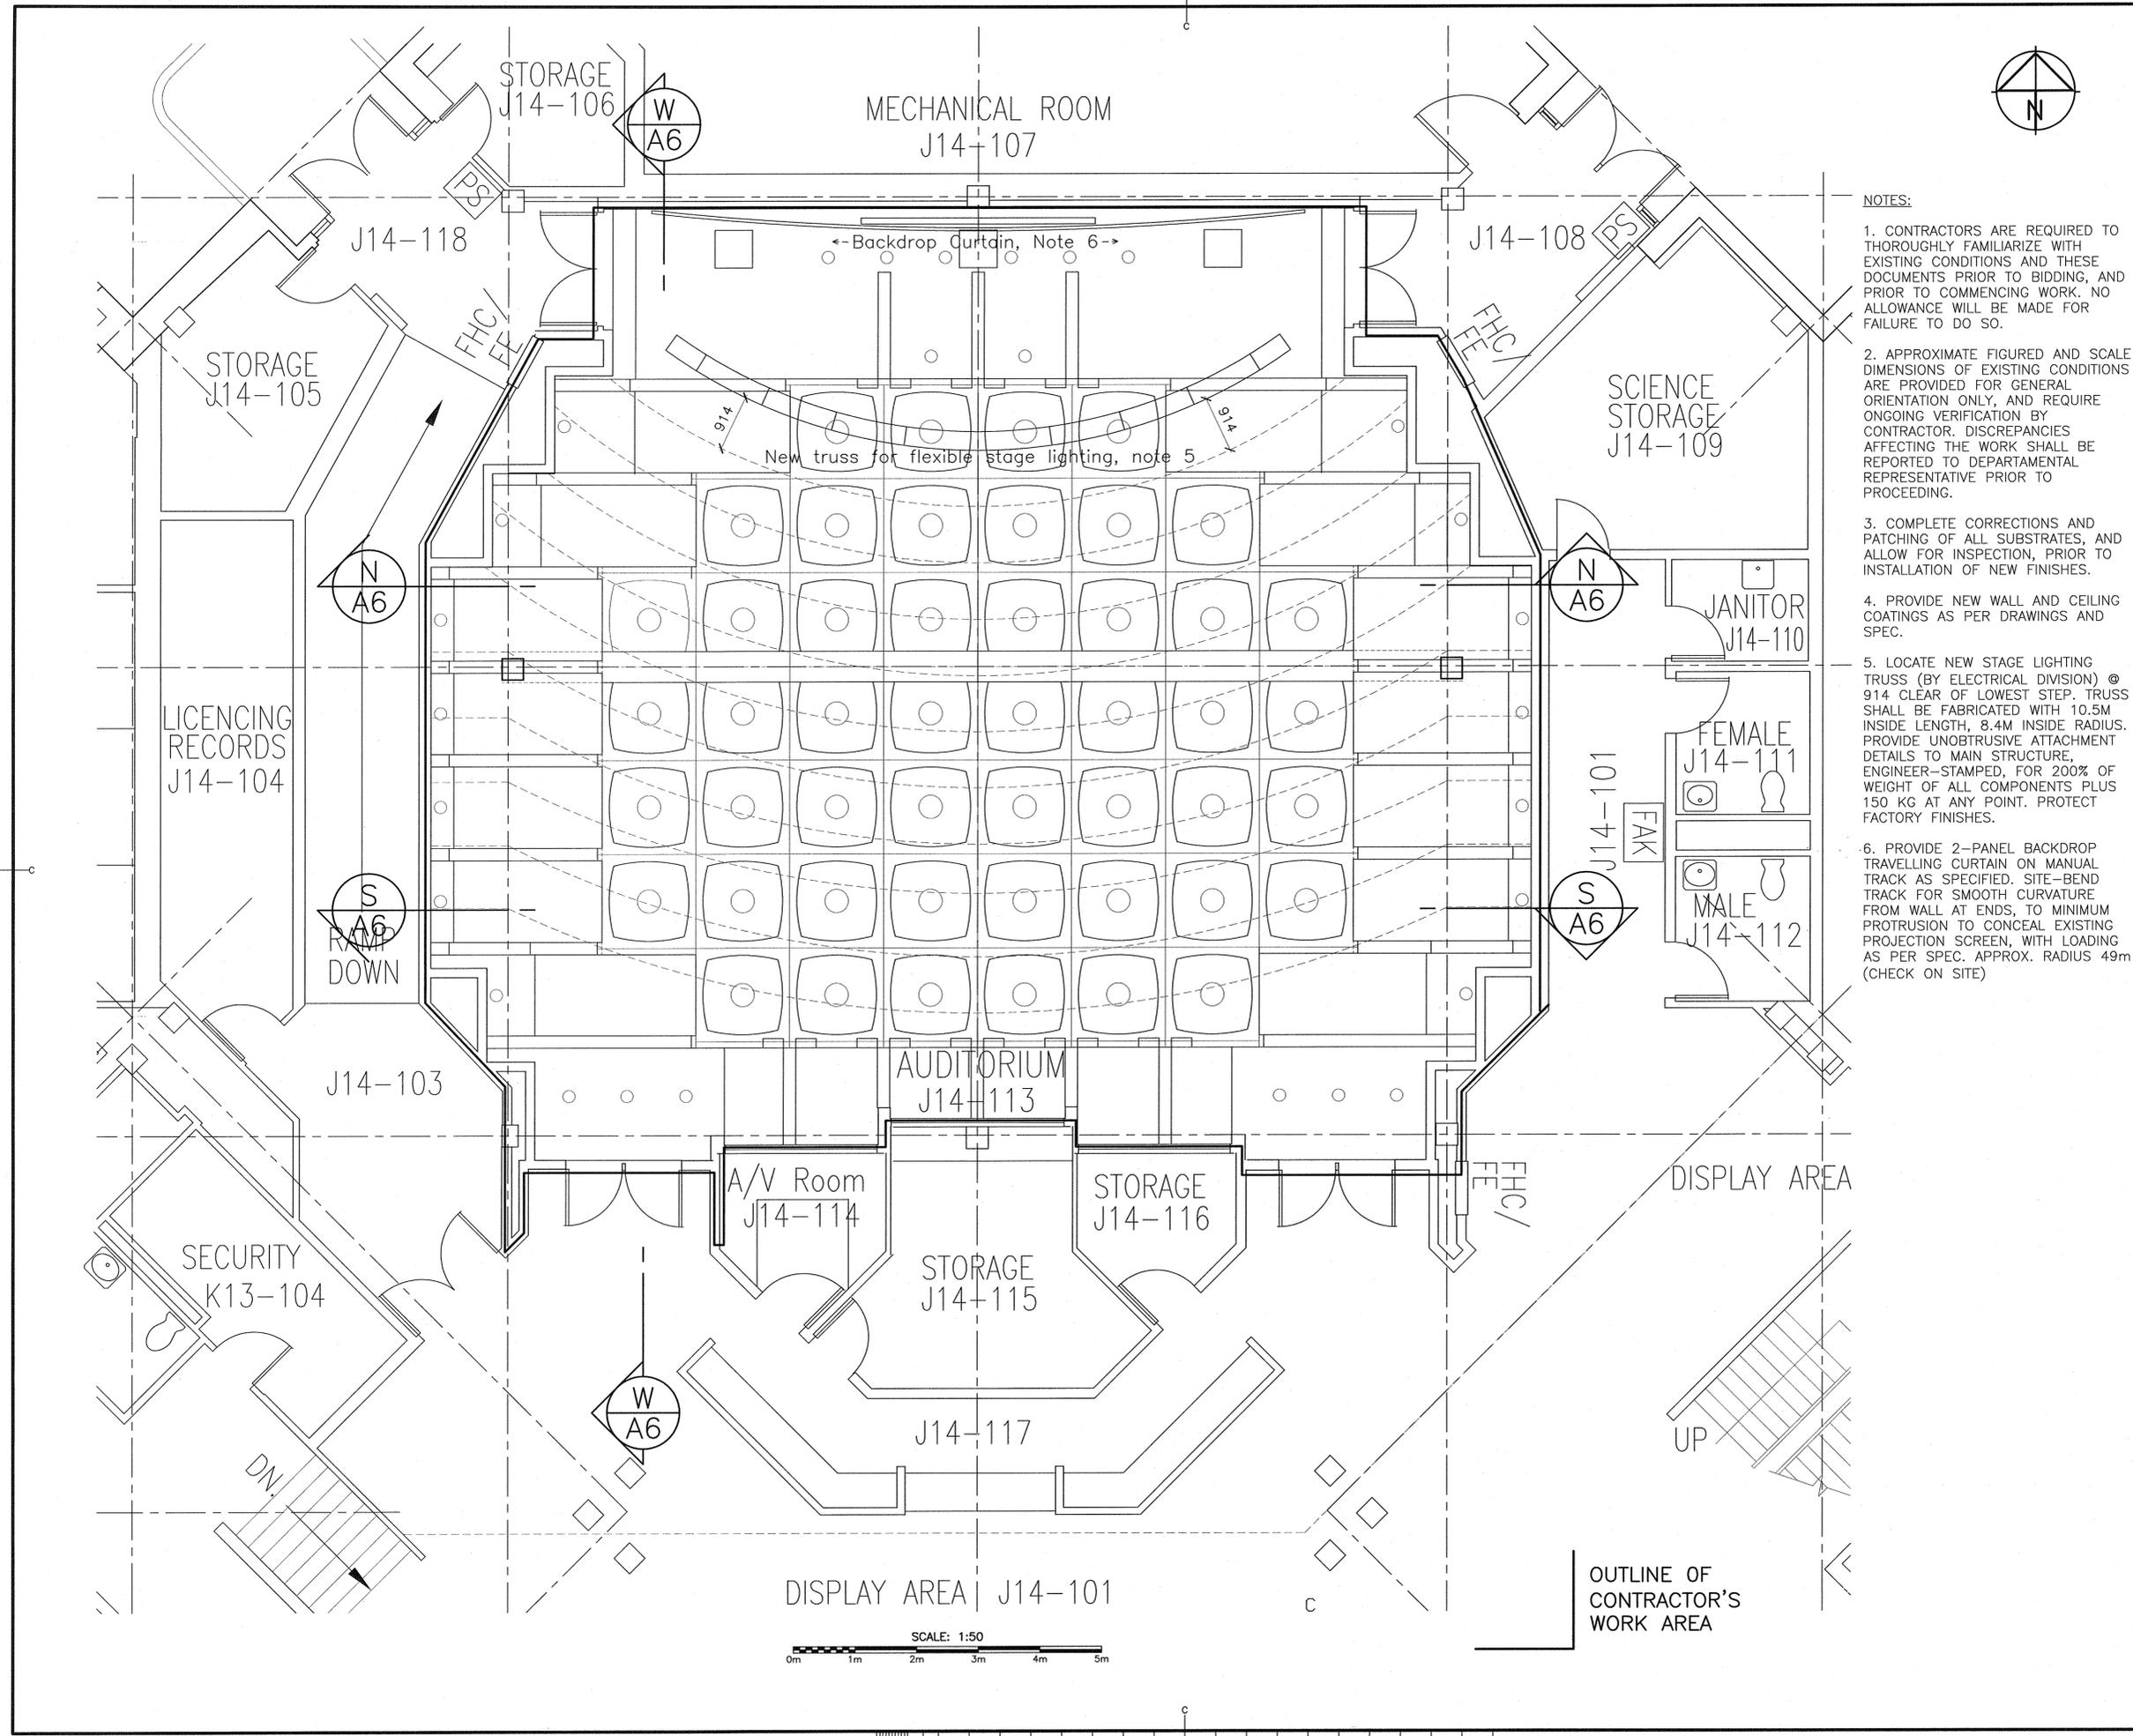

SCALE: 1:50  
0m 1m 2m 3m 4m 5m