




FRP Grating System

- BUILDING IDENTIFIER**
1. ADMINISTRATION BUILDING
 2. GARAGE AND STORAGE
 3. CONSTRUCTION TRAILER
 4. EMERGENCY GENERATOR
 5. BUILDING
 6. AERATION TOWER
 7. QUONSET - HUT
 8. STORAGE
 9. BROODSTOCK FACILITY
 10. SORTING FACILITY
 11. INFORMATION HUT
- NOTES**
ALL BUILDING SIZES AND LOCATIONS ARE APPROXIMATE

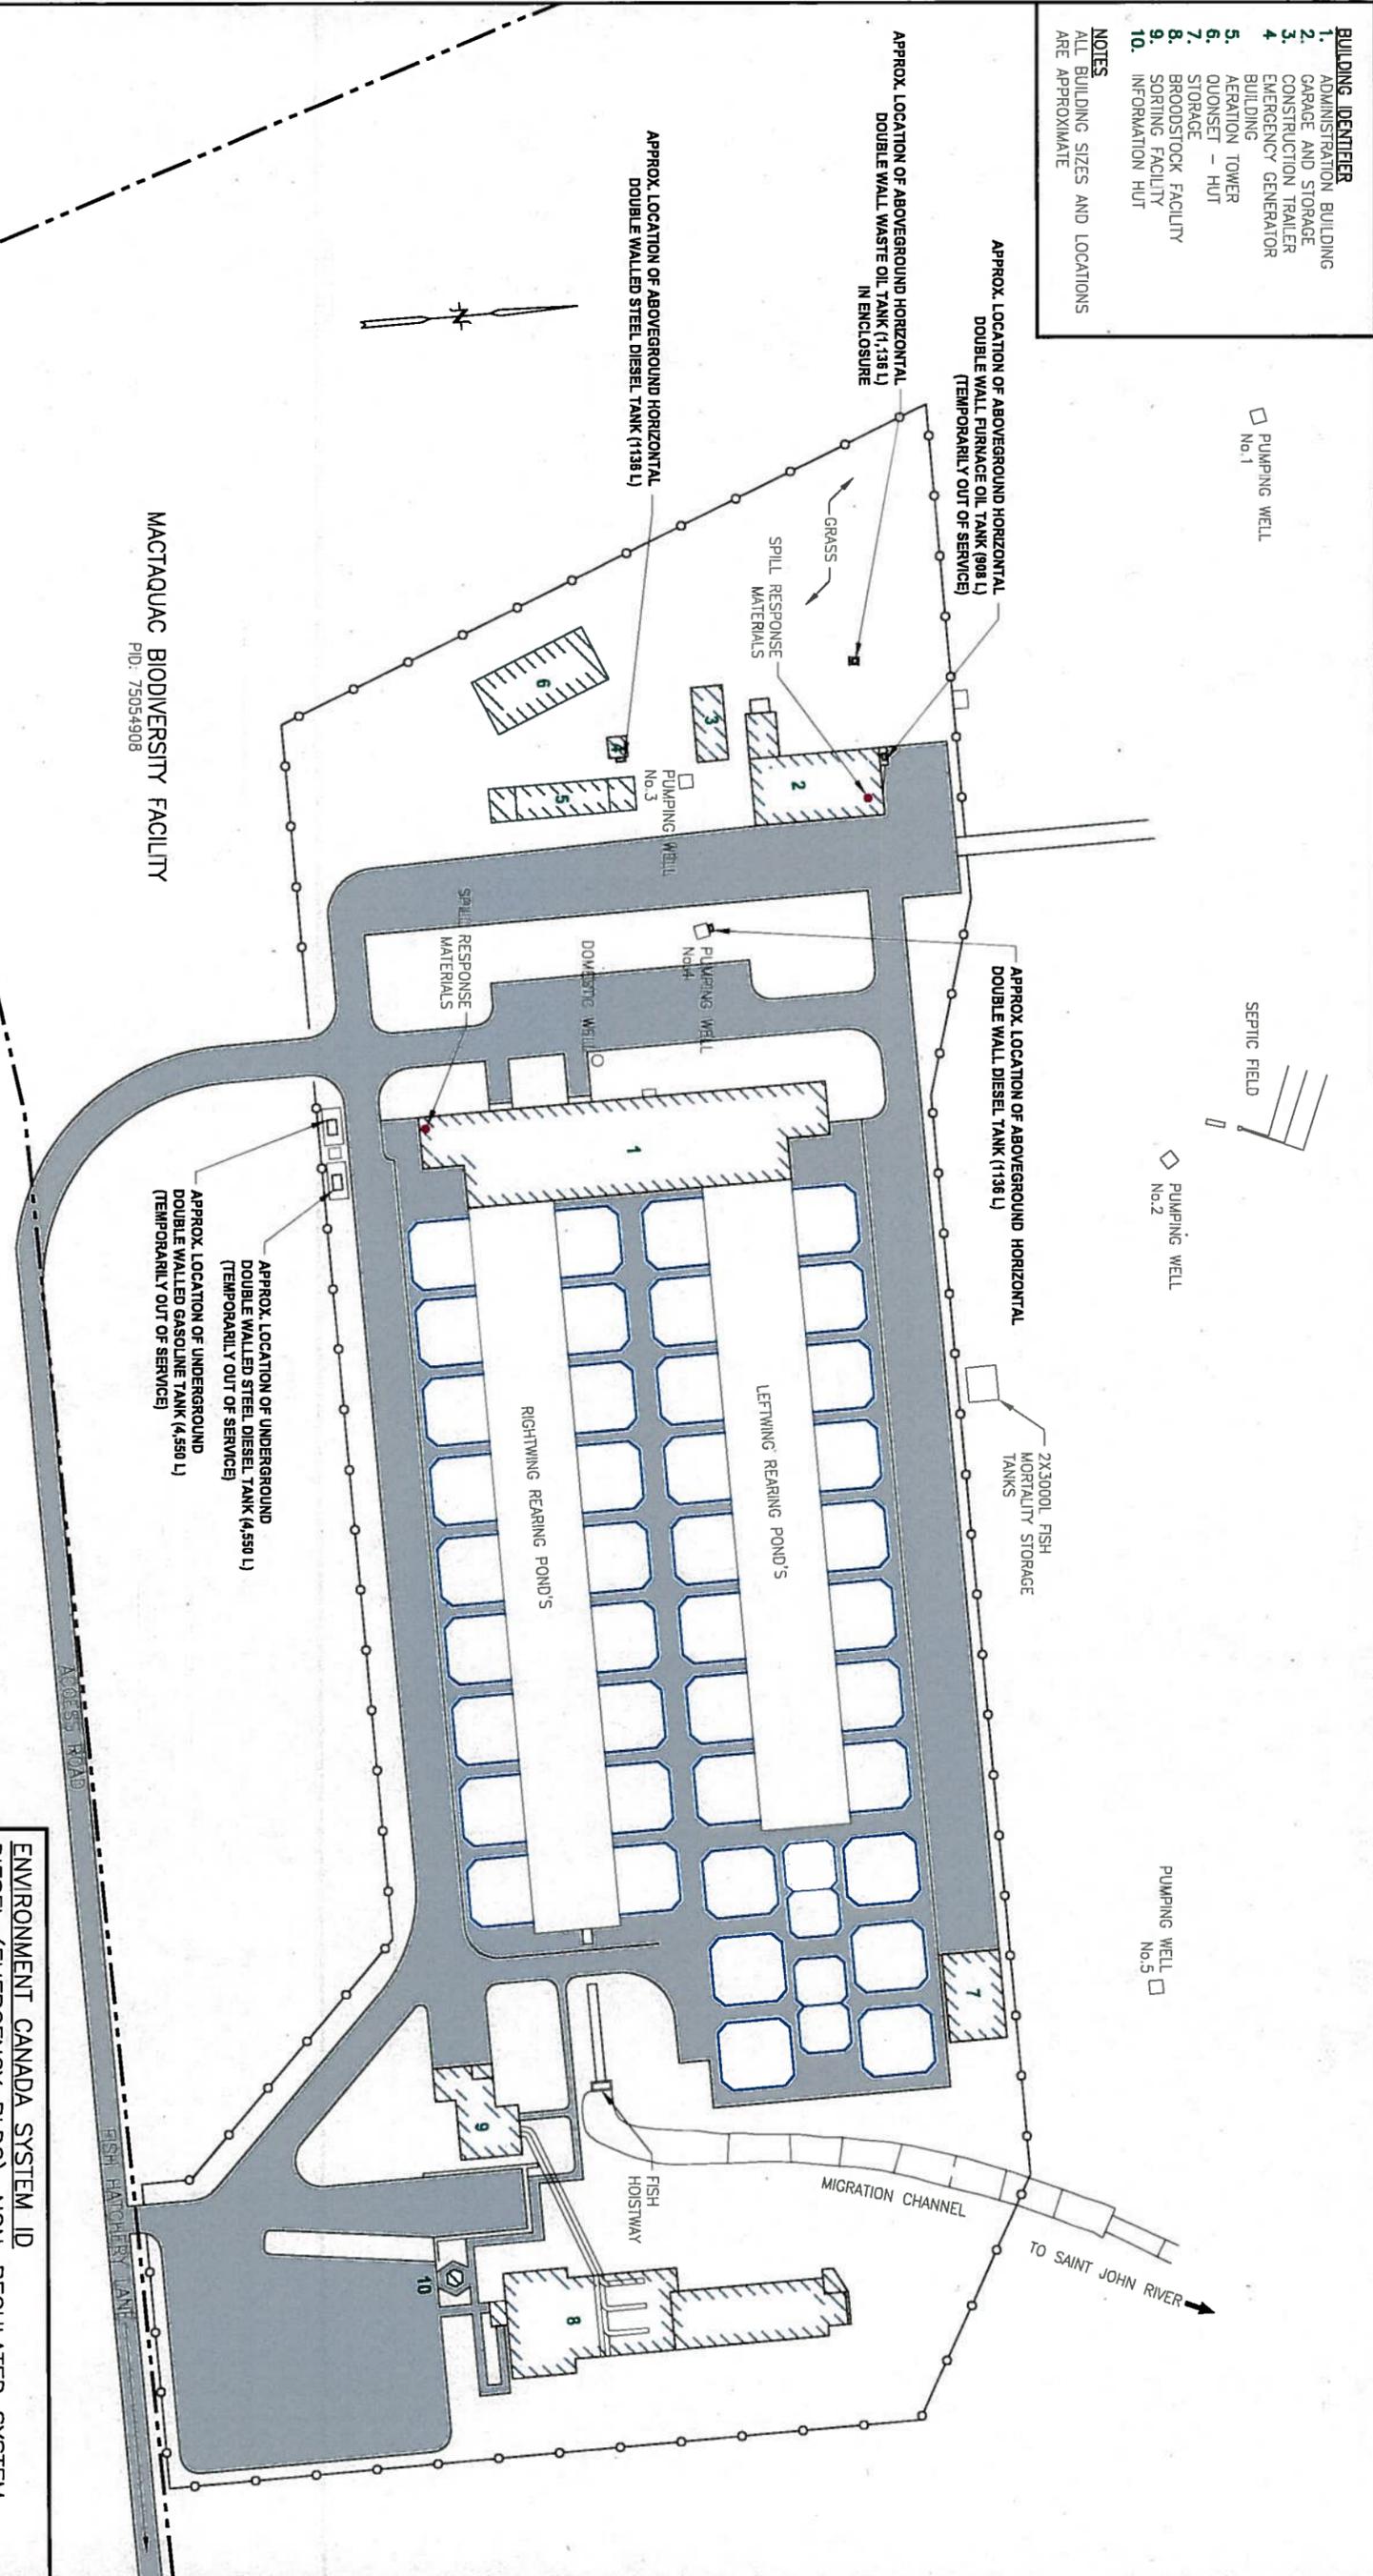

NOTE: THIS DRAWING ILLUSTRATES INFORMATION SPECIFIC TO A STANTEC CONSULTING LTD. PROJECT AND MUST NOT BE USED FOR OTHER PURPOSES.

Reference:	Scale:	1:1000	Job No.:	134230666
Date:	11 12 14		Client:	DFO RPSS
Dwn. By:	MDC			
App'd By:	ERF			

EMERGENCY PLAN
PETROLEUM STORAGE SYSTEMS
MACTAQUAC BIODIVERSITY FACILITY
MACTAQUAC, KINGSCLEAR, NB

SITE PLAN


Dwg. No.: 1

ENVIRONMENT CANADA SYSTEM ID
DIESEL (EMERGENCY BLDG): NON-REGULATED SYSTEM
WASTE OIL: EC-00001167
DIESEL & GASOLINE (DISPENSING): EC-00000525
FURNACE (PUMP WELL #4 BLDG): NON-REGULATED SYSTEM
FURNACE OIL (908 L): NON-REGULATED SYSTEM

Office Building

ADMINISTRATION
17' x 1' (entrance)
57' x 1' (entrance)

SEE DETAIL "A"

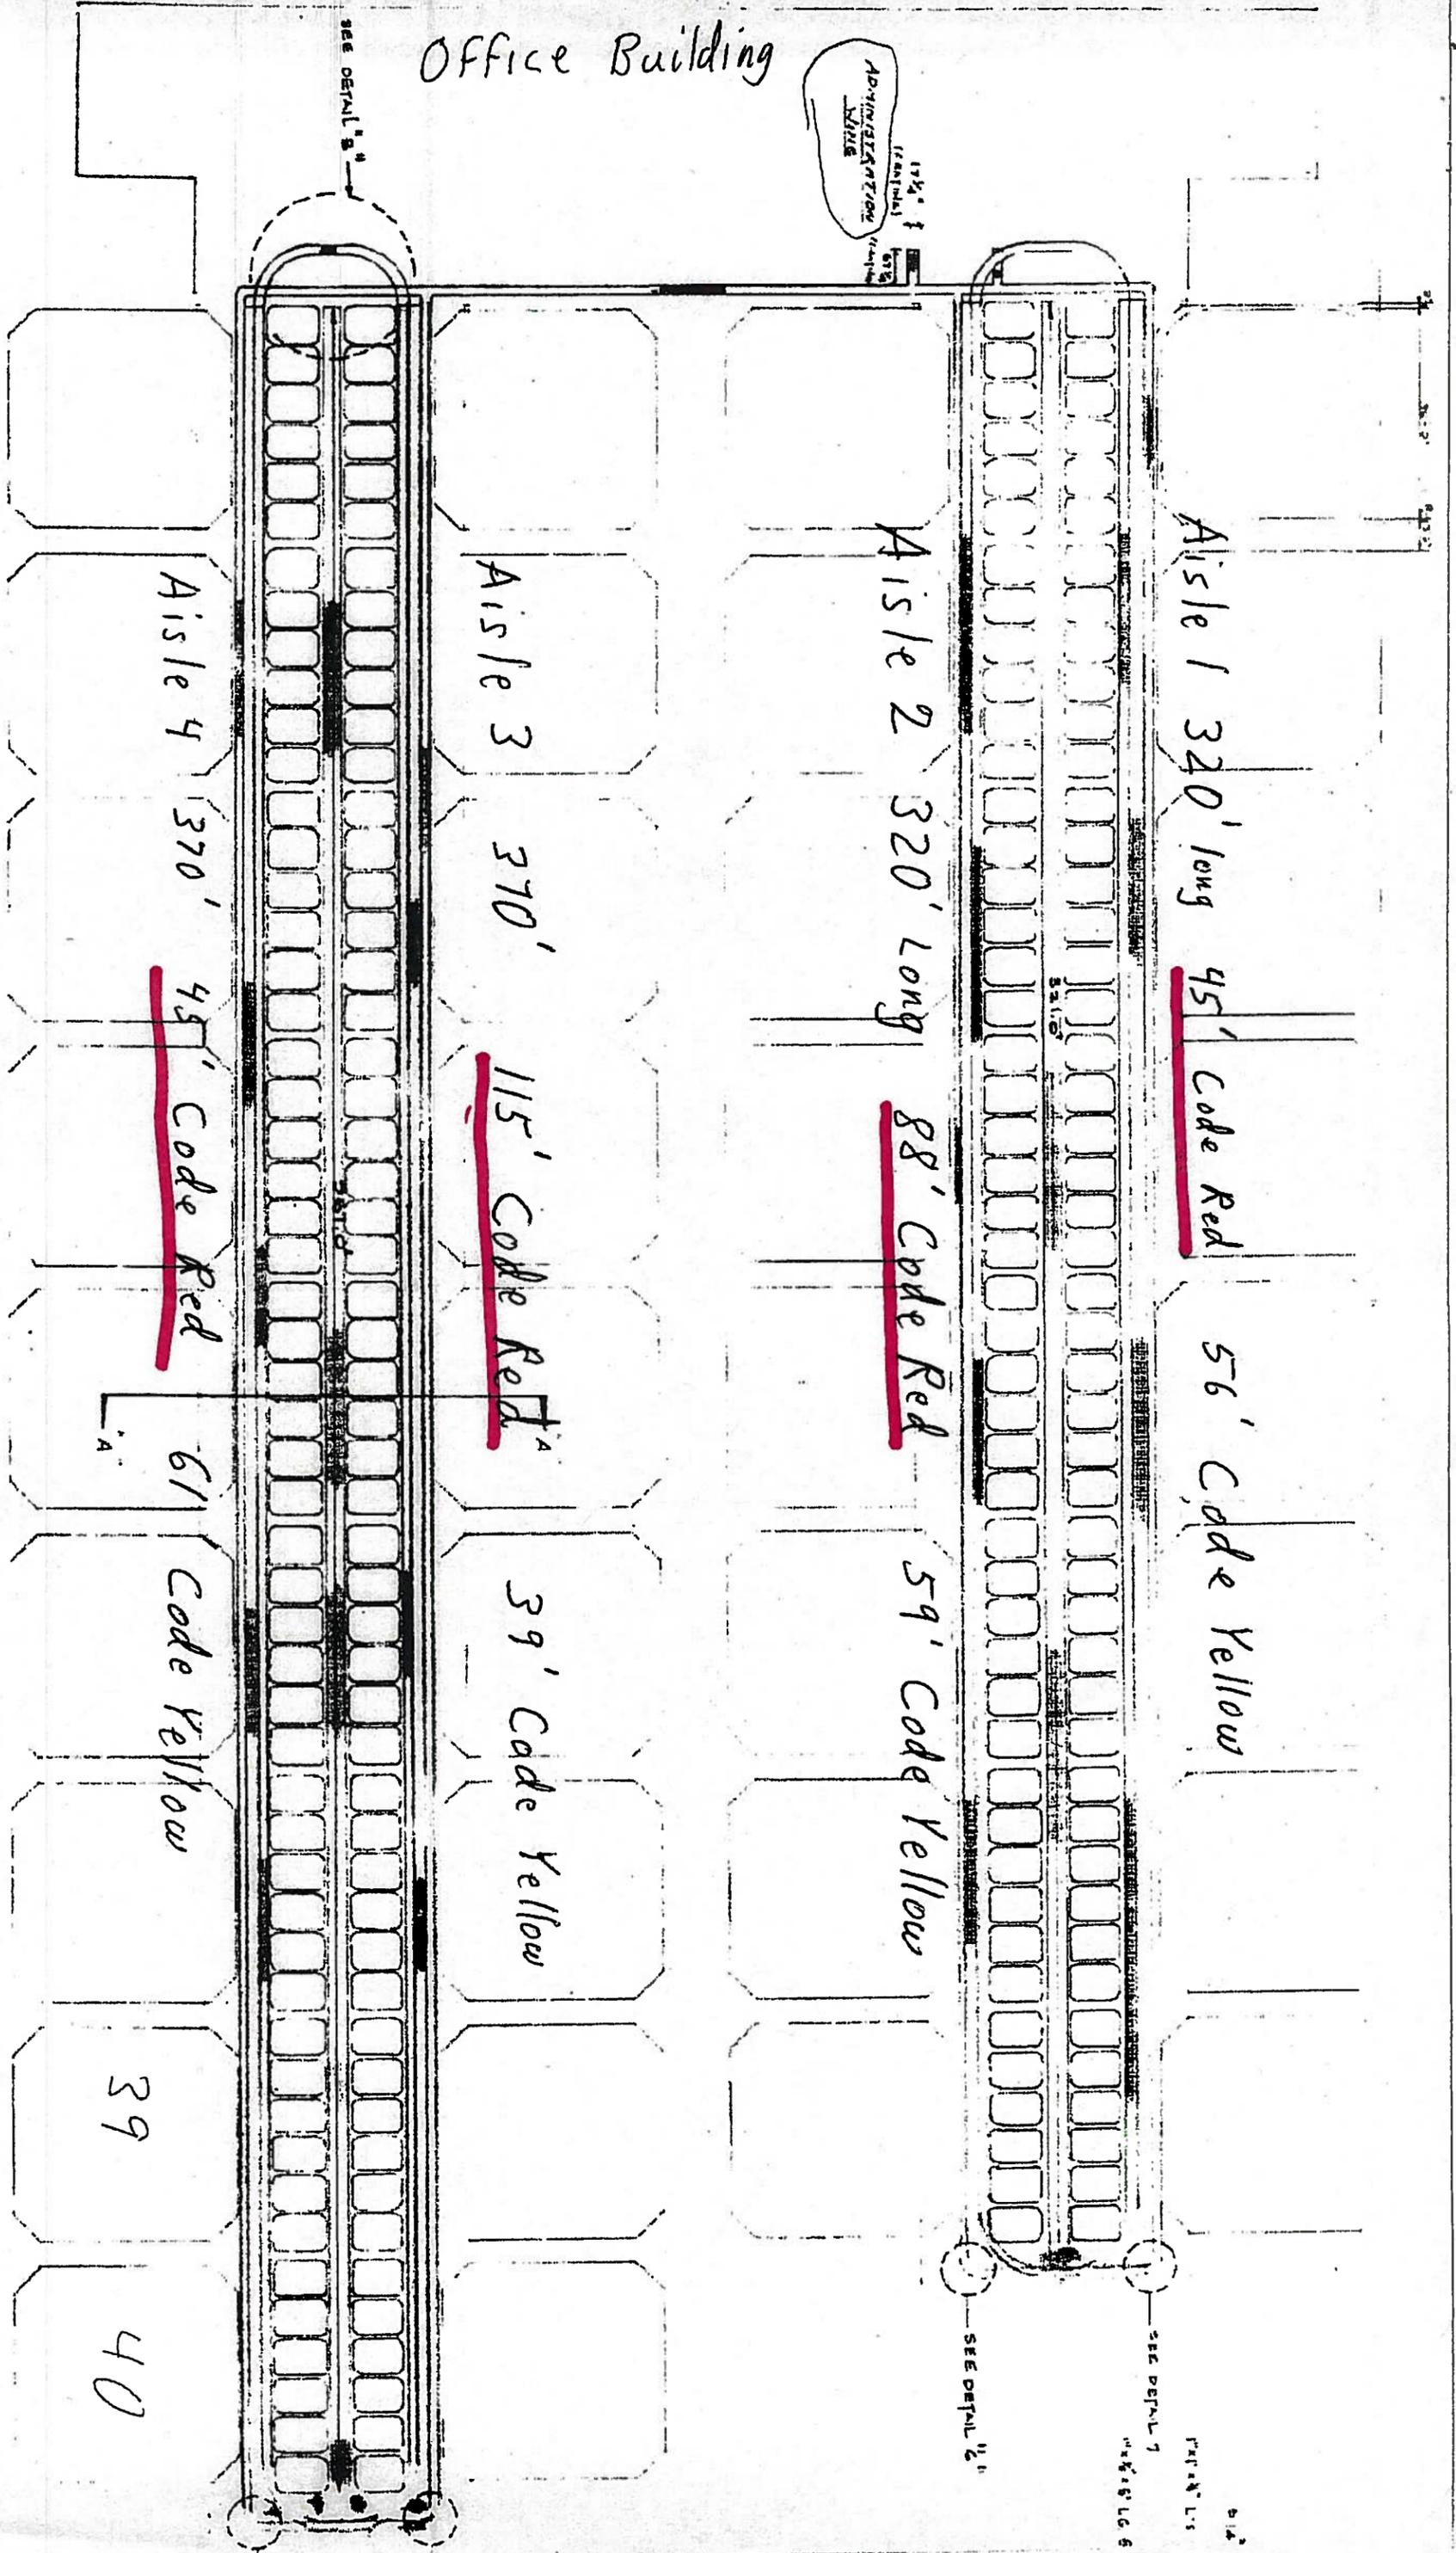

Aisle 1 320' long 45' Code Red

56' Code Yellow

Aisle 2 320' long 88' Code Red

59' Code Yellow

Aisle 3 370' 115' Code Red

39' Code Yellow

Aisle 4 370' 45' Code Red

61' Code Yellow

39

40

SEE DETAIL "1"

SEE DETAIL "2"

512' x 115'

512' x 115'