


  
**Riggs Engineering Ltd.**  
 1240 Commissioners Rd. W, Suite 205  
 London, Ontario,  
 N6K 1C7  
 Tel: (519) 657-1040  
 Fax: (519) 657 8631  
 Website: www.riggsengineering.com

- 1 Detail No.
- 2 drawing no. - where detail required refers to MA-
- 3 drawing no. - where detailed refers to MA-

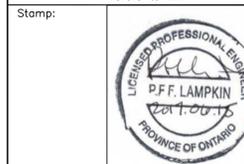

NOTES:

REVISIONS:	DATE:
1 ISSUED FOR TENDER	JUNE/23/2017

SCALE: AS NOTED CLASS:

PROJECT:  
**2017 EAST HARBOUR WALL REPAIRS**

DESCRIPTION:  
**2011 EAST SIDE ELECTRICAL SERVICES**


DRAWN: AV APPROVED: PL

DATE: 2017-03-31 DATE: 2017-03-31

LOCATION:  
**WHEATLEY, ONTARIO**

DRAWING NO.: MA-14 LOCATOR CODE: F2930-160026

- GENERAL NOTES**
1. THE POSITION OF ALL POLE LINES, CONDUITS, WATERMANS, SOWERS AND OTHER UNDERGROUND UTILITIES AND STRUCTURES ARE NOT NECESSARILY SHOWN, AND WHERE SHOWN, THE ACCURACY OF THE LOCATION SHOWN OF SUCH UTILITIES IS NOT GUARANTEED. BEFORE STARTING WORK, THE CONTRACTOR SHALL CONTACT ALL SUCH UTILITIES INVOLVED AND INFORM HIMSELF AS TO THE EXACT LOCATION OF ALL SUCH UTILITIES AND STRUCTURES AND SHALL ASSUME LIABILITY FOR DAMAGE TO THEM.
  2. ALL DIMENSIONS ARE IN METERS UNLESS OTHERWISE NOTED.
  3. ALL ELECTRICAL WORKS TO BE UNDERTAKEN WITHIN THE FEDERAL PROPERTY LIMITS. SEE DRAWING FOR DETAILS.
  4. PROVIDE A SEPARATE PRICE FOR REMOVAL OF EXISTING WOODEN POWER POLES AND OVERHEAD CONDUCTORS.

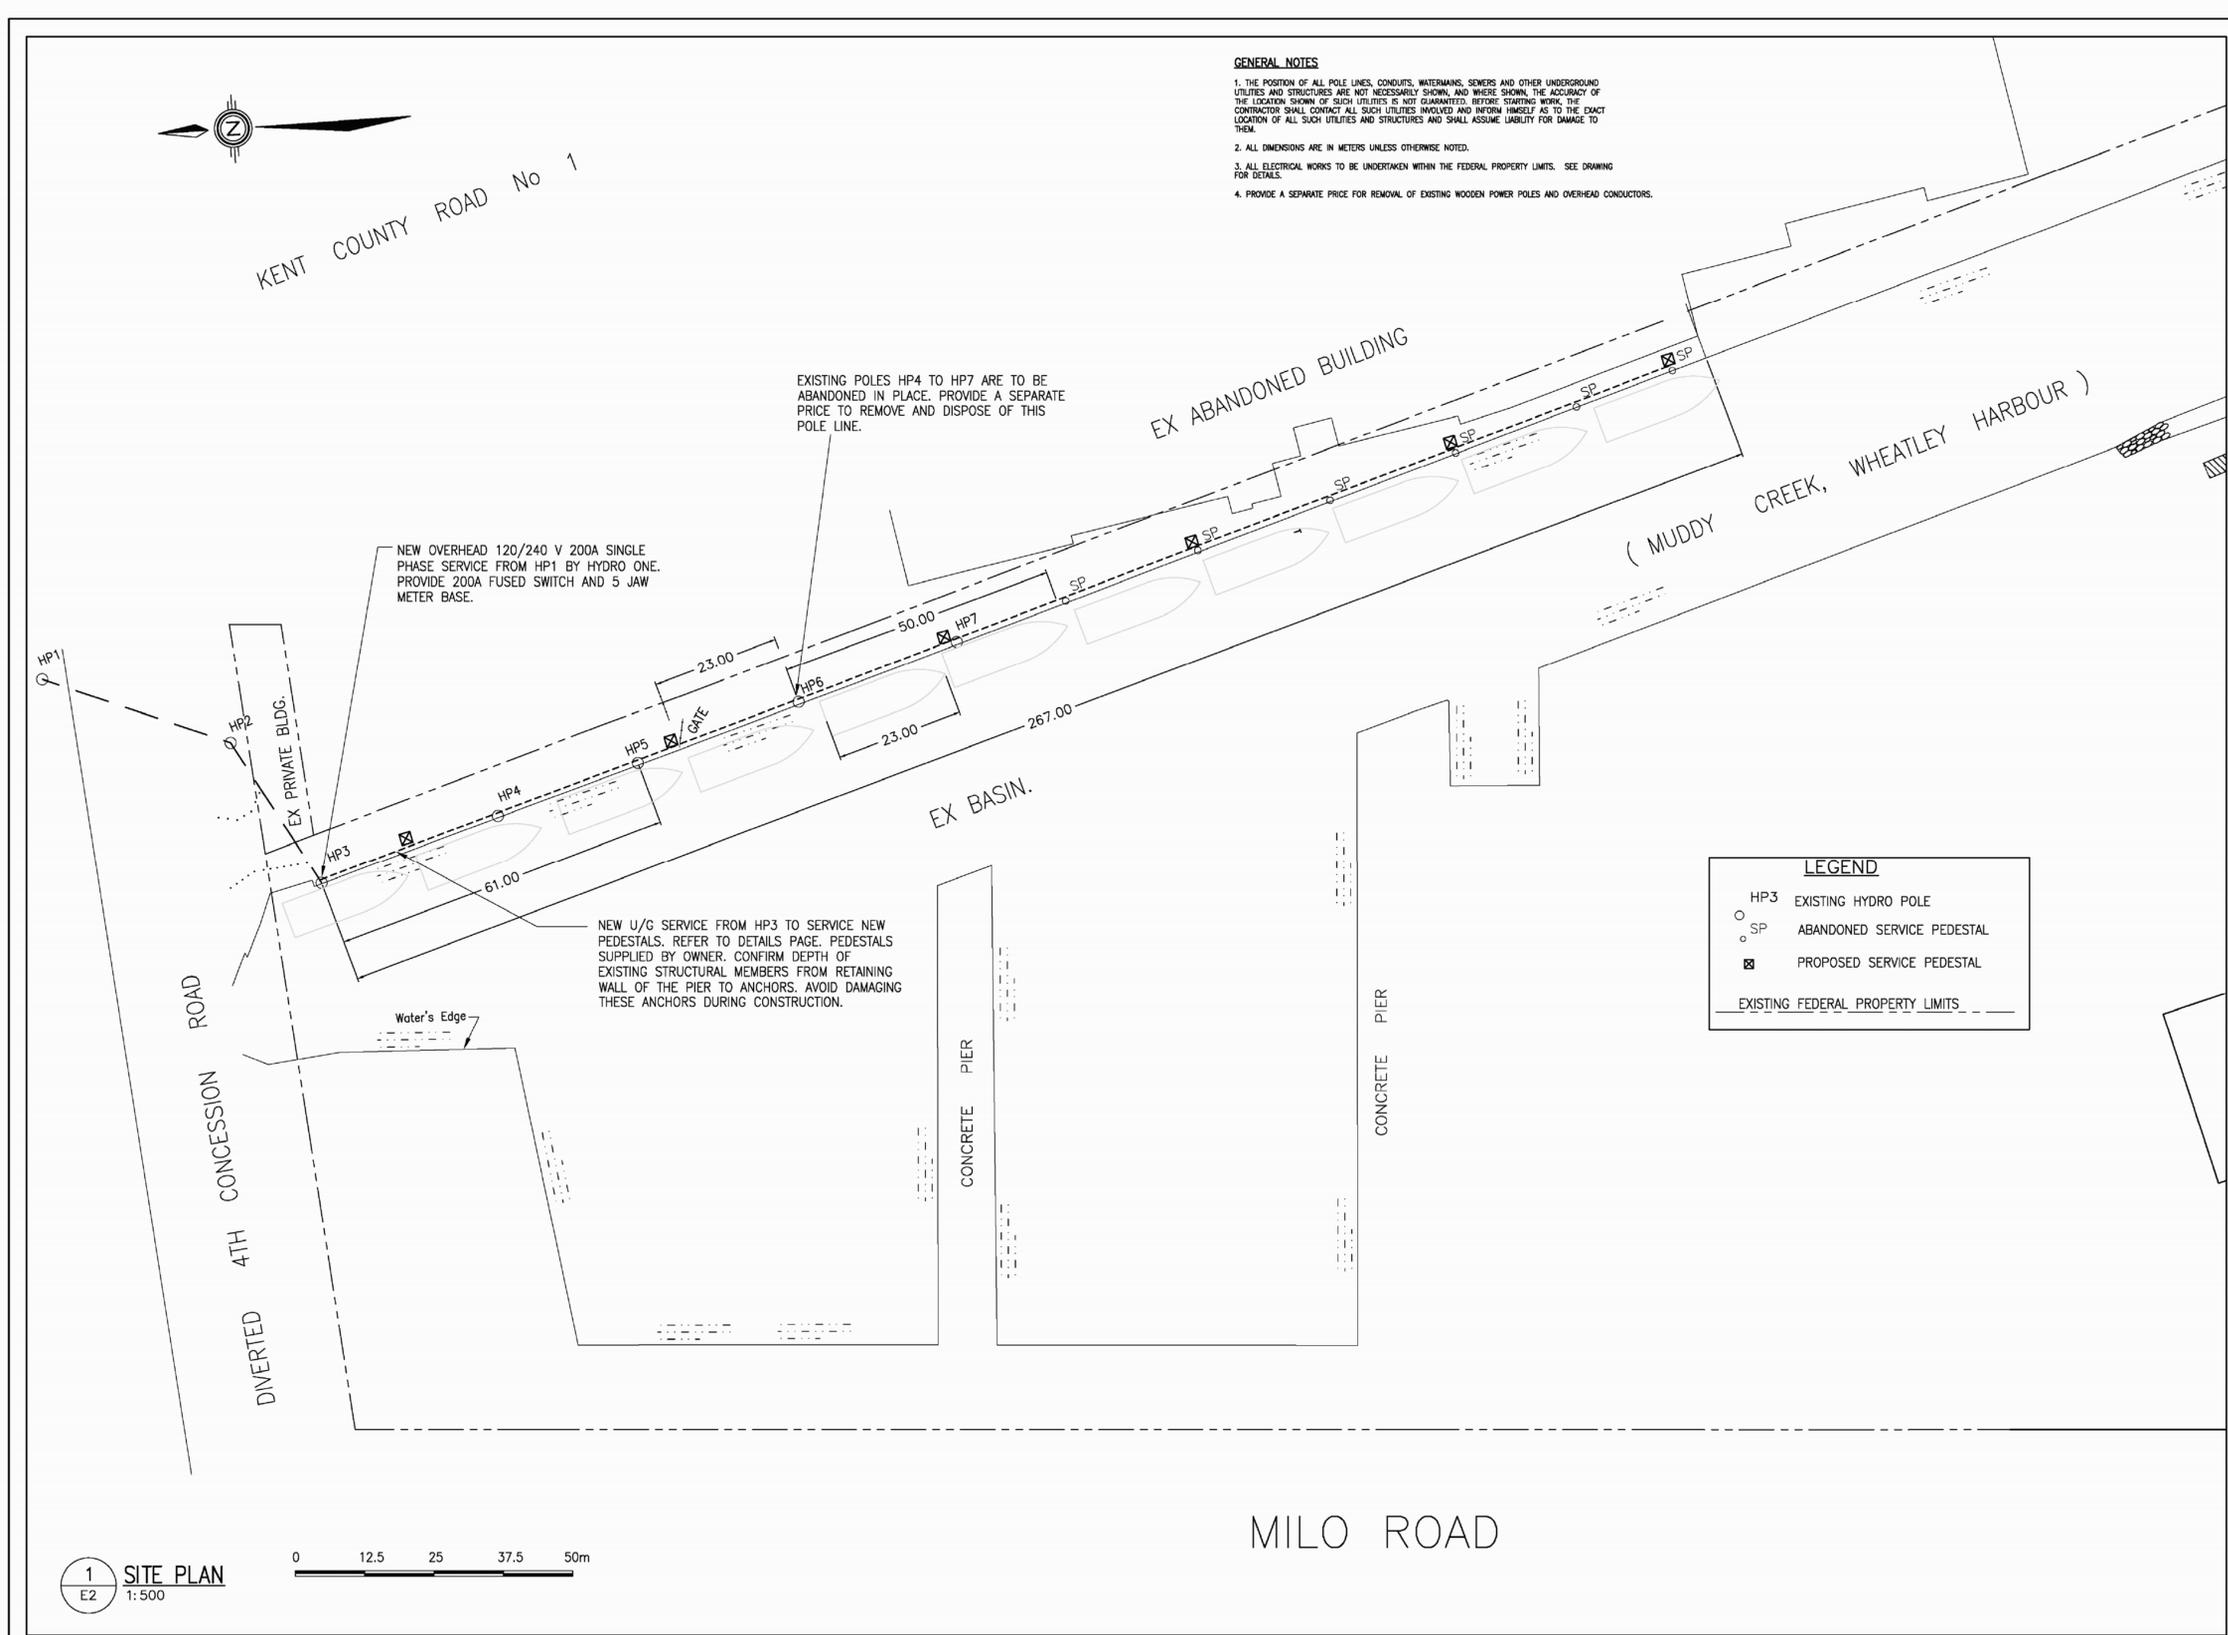

KENT COUNTY ROAD No 1

EX ABANDONED BUILDING

( MUDDY CREEK, WHEATLEY HARBOUR )

EX BASIN.

CONCRETE PIER

MILO ROAD

DIVERTED 4TH CONCESSION ROAD

Water's Edge



1 SITE PLAN  
E2 1:500

SCALE: AS SHOWN	FILE: 4684	DATE: DEC 2011	CHD: TT
EAST SIDE ELECTRICAL SERVICE	DESIGN: TT	DATE: DEC 2011	CHD: TT
WHEATLEY, ONTARIO	DRWN: TT	DATE: DEC 2011	CHD: TT
ELECTRICAL PLAN			E2
1930 Blue Heron Drive London, ON N6H 5L9 TEL: 519-472-2808 519-472-2809 www.riggsengineering.ca			
			
DO NOT SCALE THE DRAWING THE CONTRACTOR SHALL VERIFY ALL DIMENSIONS AND CONDITIONS ON THE FIELD THE CONTRACTOR SHALL BE RESPONSIBLE FOR OBTAINING ALL NECESSARY PERMITS THE CONTRACTS OF THIS COMPANY REMAINS THE PROPERTY OF INTEGRATED ENGINEERING			
NO	DATE	ISSUED FOR TENDER	DESCRIPTION
1	11.12.23	ISSUED FOR TENDER	
0	11.12.08	ISSUED FOR REVIEW	