
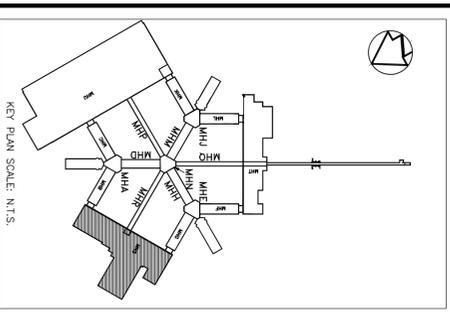


1	2
PROVIDE ALL NEW CONDUIT AND WIRING REUSE CIRCUITS EPS6-3 AND EPS6-1 FOR TUNNEL LIGHTING.	EXISTING D.C. BATTERY UNIT, TRACE OUT AND MAINTAIN FUNCTIONALITY OF EXISTING EMERGENCY LIGHTING.

FIXTURE TYPE	DESCRIPTION	MANUFACTURER	MODEL NO.	OR EQUIVALENT BY
P01	1200mm CHAIN SUSPENDED LED FIXTURE C/W SEMI FROST ACRYLIC LENS, 6096 LUMENS, 51 WATTS, 3500K CCT, 120V, 0-10V DIMMING DRIVER, CHAIN HANGING KIT. LENGTH OF CHAIN TO SUIT APPLICATION.	EATON METALUX	4SNLED-LD4-60SL-LN-UV-L835-001-U	LITHONIA PHILIPS
P02	1200mm CHAIN SUSPENDED LED FIXTURE C/W SEMI FROST ACRYLIC LENS, 2660 LUMENS, 22 WATTS, 3500K CCT, 120V, 0-10V DIMMING DRIVER, CHAIN HANGING KIT. LENGTH OF CHAIN TO SUIT APPLICATION.	EATON METALUX	4SNLED-LD4-26SL-LN-UV-L835-001-U	LITHONIA PHILIPS

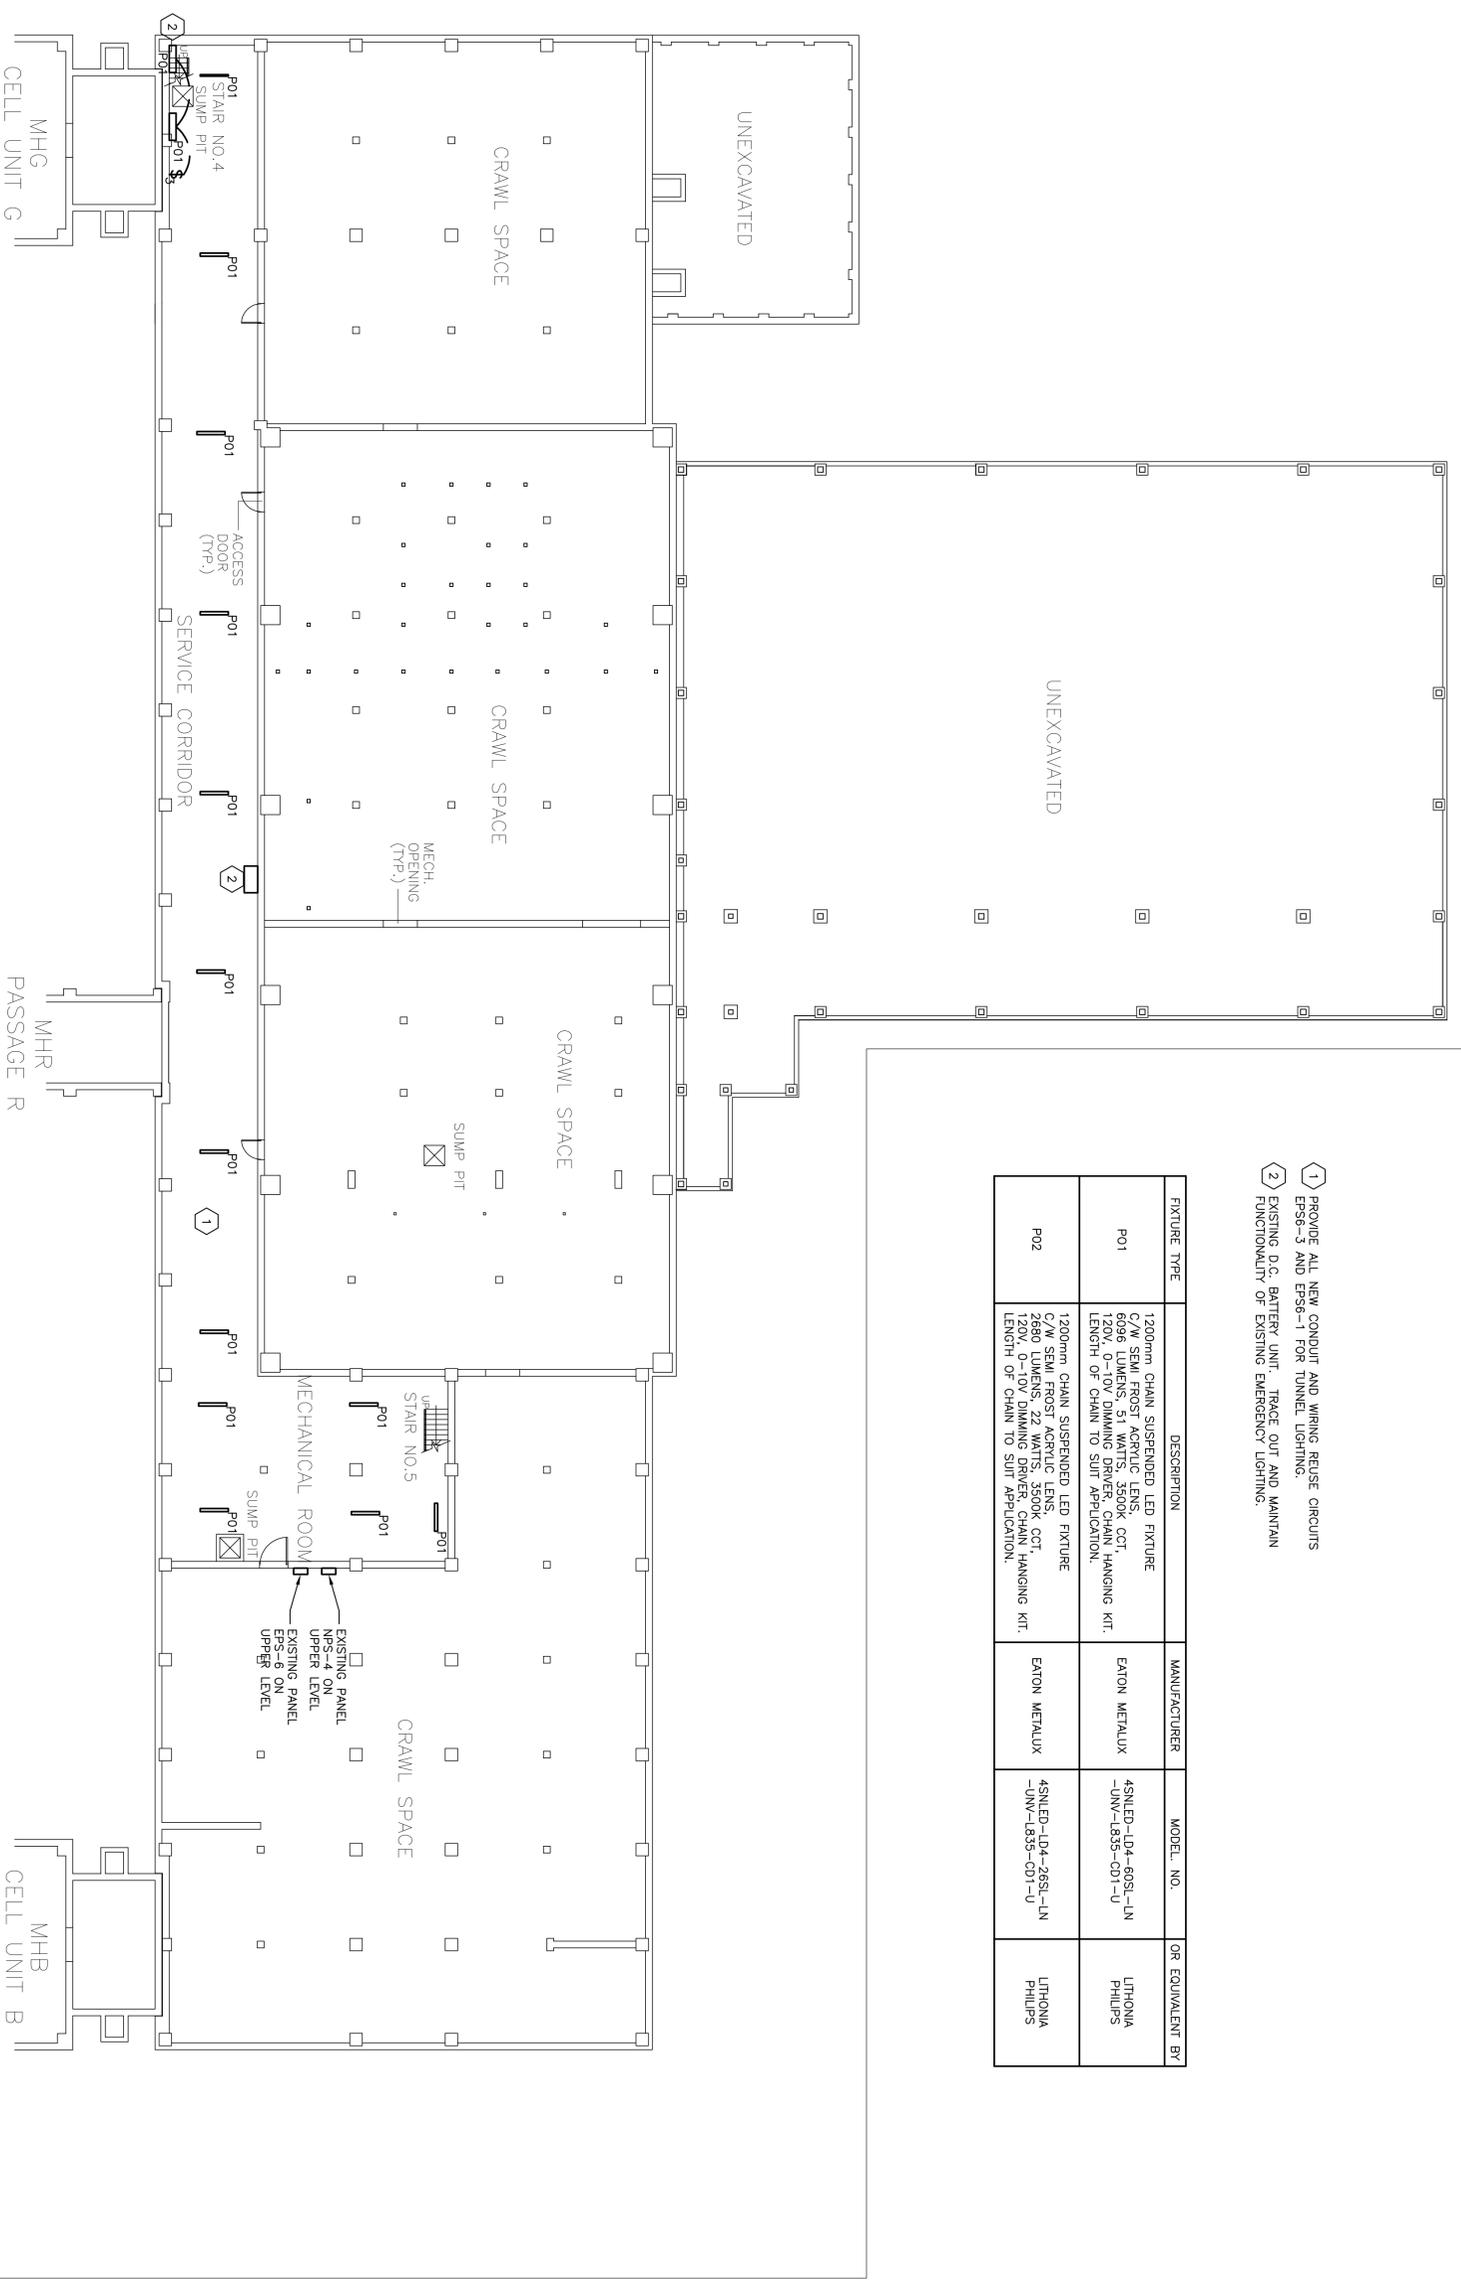

NO.	DESCRIPTION	DATE	BY
0	ISSUED FOR TENDER	MA-31-2017	RV

REVISIONS



NOT TO BE USED FOR CONSTRUCTION UNLESS SIGNED BY THE ENGINEER.

THIS DRAWING IS AN INSTRUMENT OF PROFESSIONAL SERVICE FOR USE EXCLUSIVELY ON THIS PROJECT. IS PROHIBITED.

Copyright 2017 Kirkland Engineering Ltd.

KIRKLAND ENGINEERING LTD.

570 Water Street
 Peterborough, Ontario
 K9H 3N8
 P: (705) 741-1526
 www.kirklandeng.com

PROJECT
 Milhaven Institution
 Tunnel Lighting
 Hwy. 33
 Bath, Ontario

TITLE
 BUILDINGS MHS
 LIGHTING PLAN

DESIGN	SCALE AS NOTED
DESIGNED: RAV	
CHECKED: KER	
APPROVED: RAV	
PROJECT: 5975	



COMP. FILE NO. 5975/53