

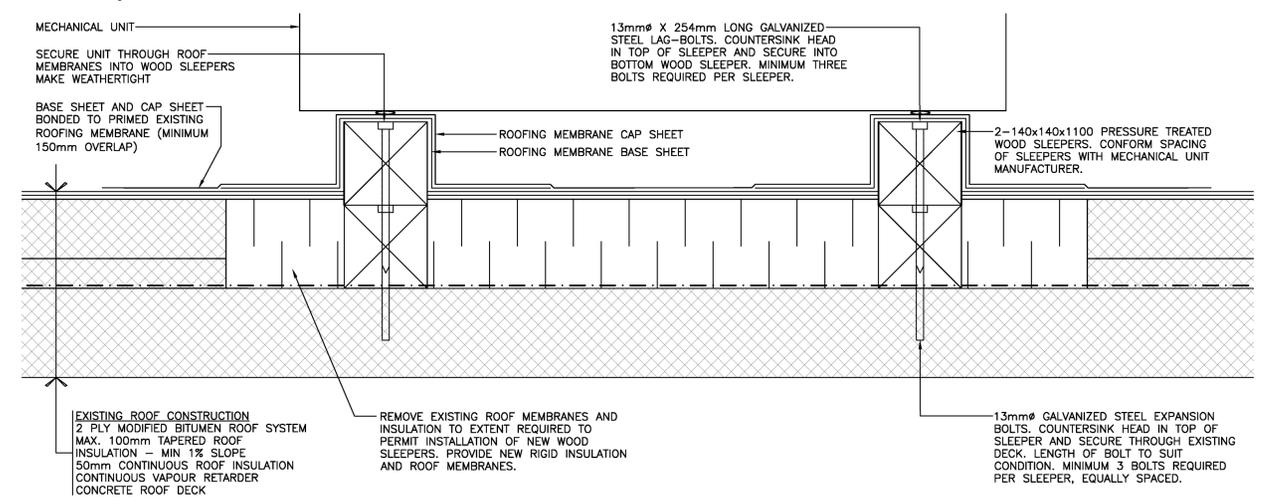



LEGEND
AIR DISTRIBUTION – DOUBLE LINE

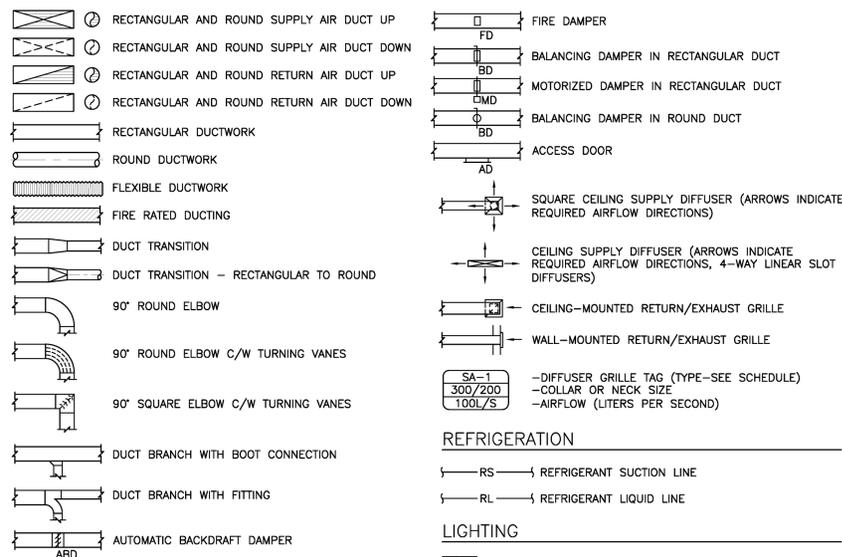


WOOD SLEEPERS FOR NEW CONDENSER UNIT
SCALE: 1:5

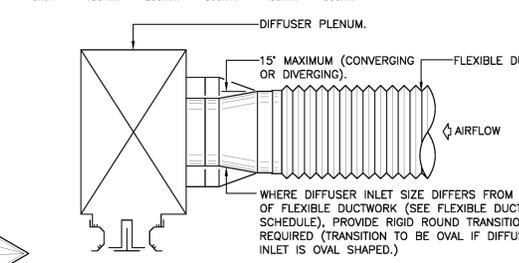


DUCT TRANSITIONS AT DIFFUSERS
SCALE: N.T.S.

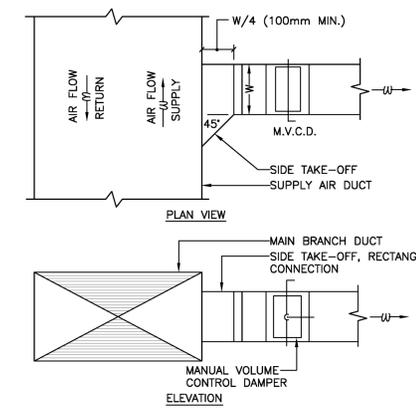


SIDE TAKE-OFF CONNECTION - RECTANGULAR DUCTS
SCALE: N.T.S.

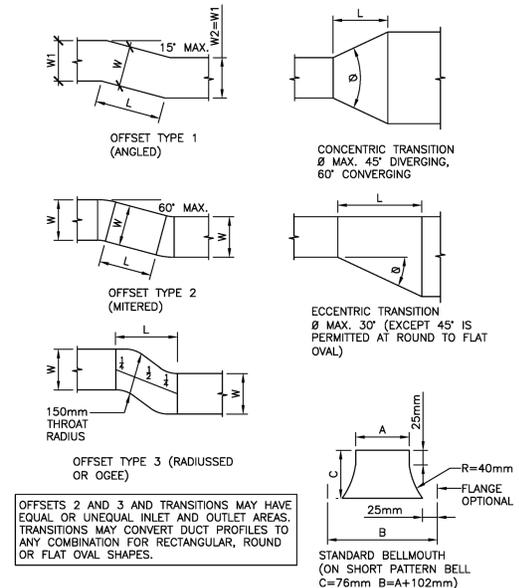


DUCT TRANSITIONS AND OFFSETS
SCALE: N.T.S.

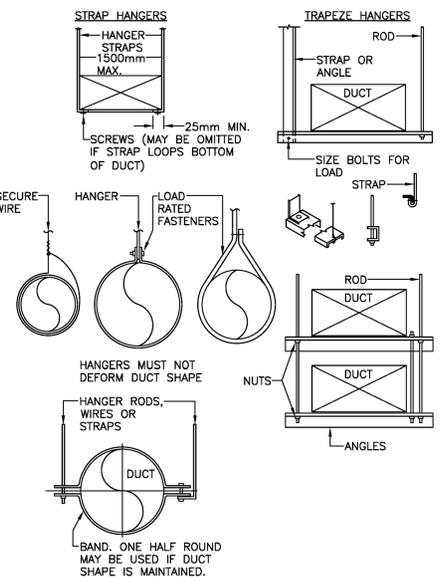


DUCT SUPPORTS
SCALE: N.T.S.

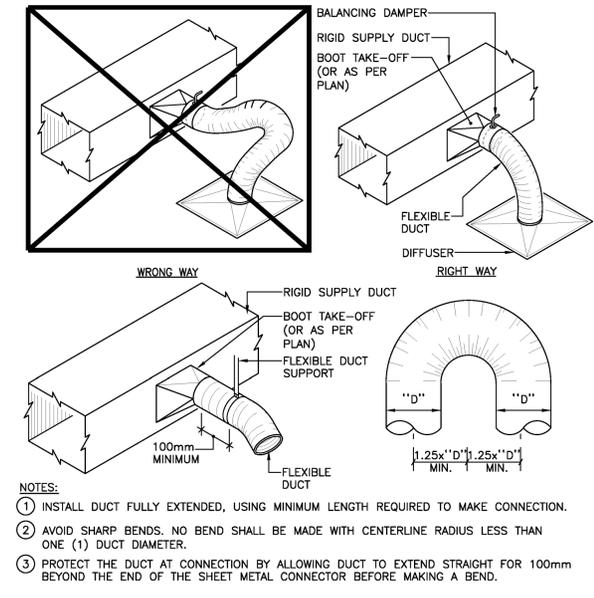

FLEXIBLE DUCT INSTALLATION DETAIL
SCALE: N.T.S.

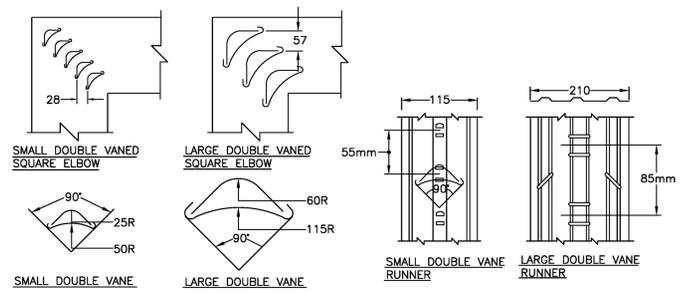

VANED ELBOW CONSTRUCTION DETAILS
SCALE: N.T.S.

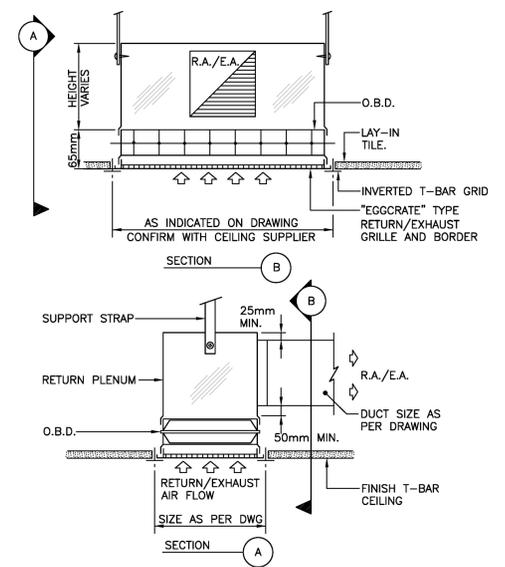


RETURN/EXHAUST AIR GRILLE
SCALE: N.T.S.


wood.
Environment and Infrastructure Solutions

PROVINCE OF NEWFOUNDLAND AND LABRADOR
PERMIT HOLDER
This Permit Allows
wood.
Environment & Infrastructure Solutions
04 JUL 2018
To practice Professional Engineering in Newfoundland and Labrador. Permit No. as issued by PEOGAL 100244 which is valid for the year 2018.

PROFESSIONAL ENGINEER
PEOGAL
DOUGLAS E. WALTERS
04 JUL 2018
NEWFOUNDLAND & LABRADOR

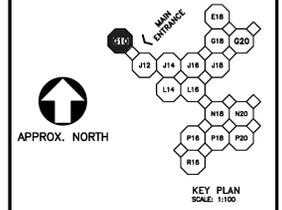

- GENERAL NOTES:**
- INSTALL ALL EQUIPMENT IN ACCORDANCE WITH MANUFACTURERS INSTRUCTIONS.
 - LOCATE ALL PENETRATIONS ON BOTH SIDES OF WALL, FLOOR, ROOF ETC PRIOR TO CUTTING.
 - REVIEW ENTIRE DUCT ROUTE PRIOR TO INSTALLATION. CONFIRM ON SITE.
 - COORDINATE INTEGRATION OF SYSTEM CONTROLS WITH OWNERS BUILDING CONTROLS SERVICE PROVIDER.
 - CONTRACTOR TO VISIT SITE PRIOR TO COMMENCING WORK. TRACE OUT ALL SYSTEMS BEFORE INITIATING WORK.
 - COORDINATE SYSTEM SHUT DOWNS & SERVICE INTERRUPTIONS WITH OWNER.

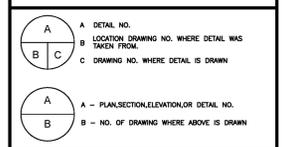

C	REISSUED FOR TENDER	JUL 4 2018
B	ISSUED FOR TENDER	JUN 8 2018
A	ISSUED FOR 99% REVIEW	APR 3 2013
revisions		date

project
NORTHWEST ATLANTIC FISHERIES CENTRE (NAFC) COOLING & VENTILATION RENOVATIONS FOR POD G10
project

MECHANICAL DETAILS AND LEGEND

designed	conju
date	04/07/2018
drawn	dessin
date	04/07/2018
approved	approuvé
date	04/07/2018
Tender	Soumission
PWGC Project Manager	Administrateur de projets TPSCC
project number	no. du projet
R.999102.002	
drawing no.	no. du dessin
H-4	