



CORRECTIONAL SERVICE CANADA STONY MOUNTAIN INSTITUTION STONY MOUNTAIN, MB

NAB STORM DRAINAGE R.086418.001

DRAWING INDEX

SHEET NUMBER	SHEET TITLE
G100	LOCATION PLAN, BASEMENT PLAN - EXISTING CONDITIONS
S101	BASEMENT PLAN - STRUCTURAL PLAN
M101	BASEMENT PLAN - MECHANICAL PIPING PLAN
M102	BASEMENT PLAN - MECHANICAL PIPING DETAILS
E101	BASEMENT PLAN - ELECTRICAL PLAN

Revision	Description	Date
5		
4	RE-ISSUED FOR TENDER (STAMPED)	2018/08/07
3	ISSUED FOR TENDER (STAMPED)	2018/05/31
2	ISSUED FOR TENDER	2018/03/29
1	99% DESIGN SUBMISSION	2018/02/21
0	50% DESIGN SUBMISSION	2017/11/23

Client: client

PUBLIC WORKS & GOVERNMENT SERVICES

100-167 LOMARD AVENUE
WINNIPEG, MB. R3B 0T6

Project: Projet

**CORRECTIONAL SERVICE CANADA
STONY MOUNTAIN INSTITUTION
STONY MOUNTAIN, MB
NAB STORM DRAINAGE**

Designed by: Conçu par

MAH

Drawn by: Dessiné par

JF

Approved by: Approuvé par

RLG

PWSSC Project Manager / Administrateur de Projets TPSGC

TIM LODGE

Drawing Title: Titre du dessin


 
INDEX PAGE

ISSUED FOR TENDER

Project no./No. du projet: R.086418.001


Drawing no./No. du dessin: **INDEX**

Revision no.: **4**

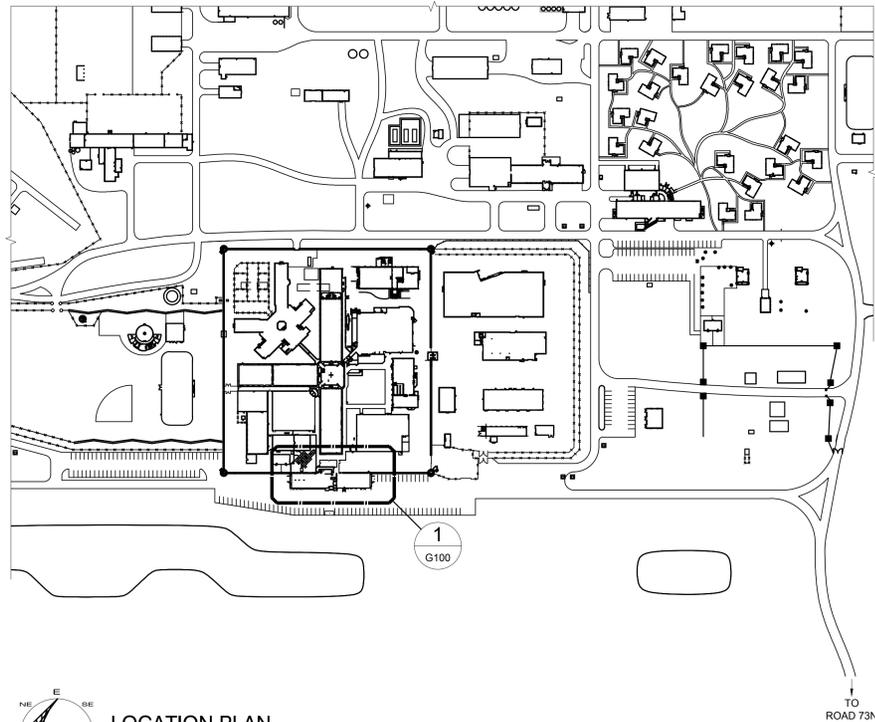

CIVIC ADDRESS:
HIGHWAY 7
STONY MOUNTAIN,
MB R0C 3A0

LOCATION PLAN
SCALE: 1:2500

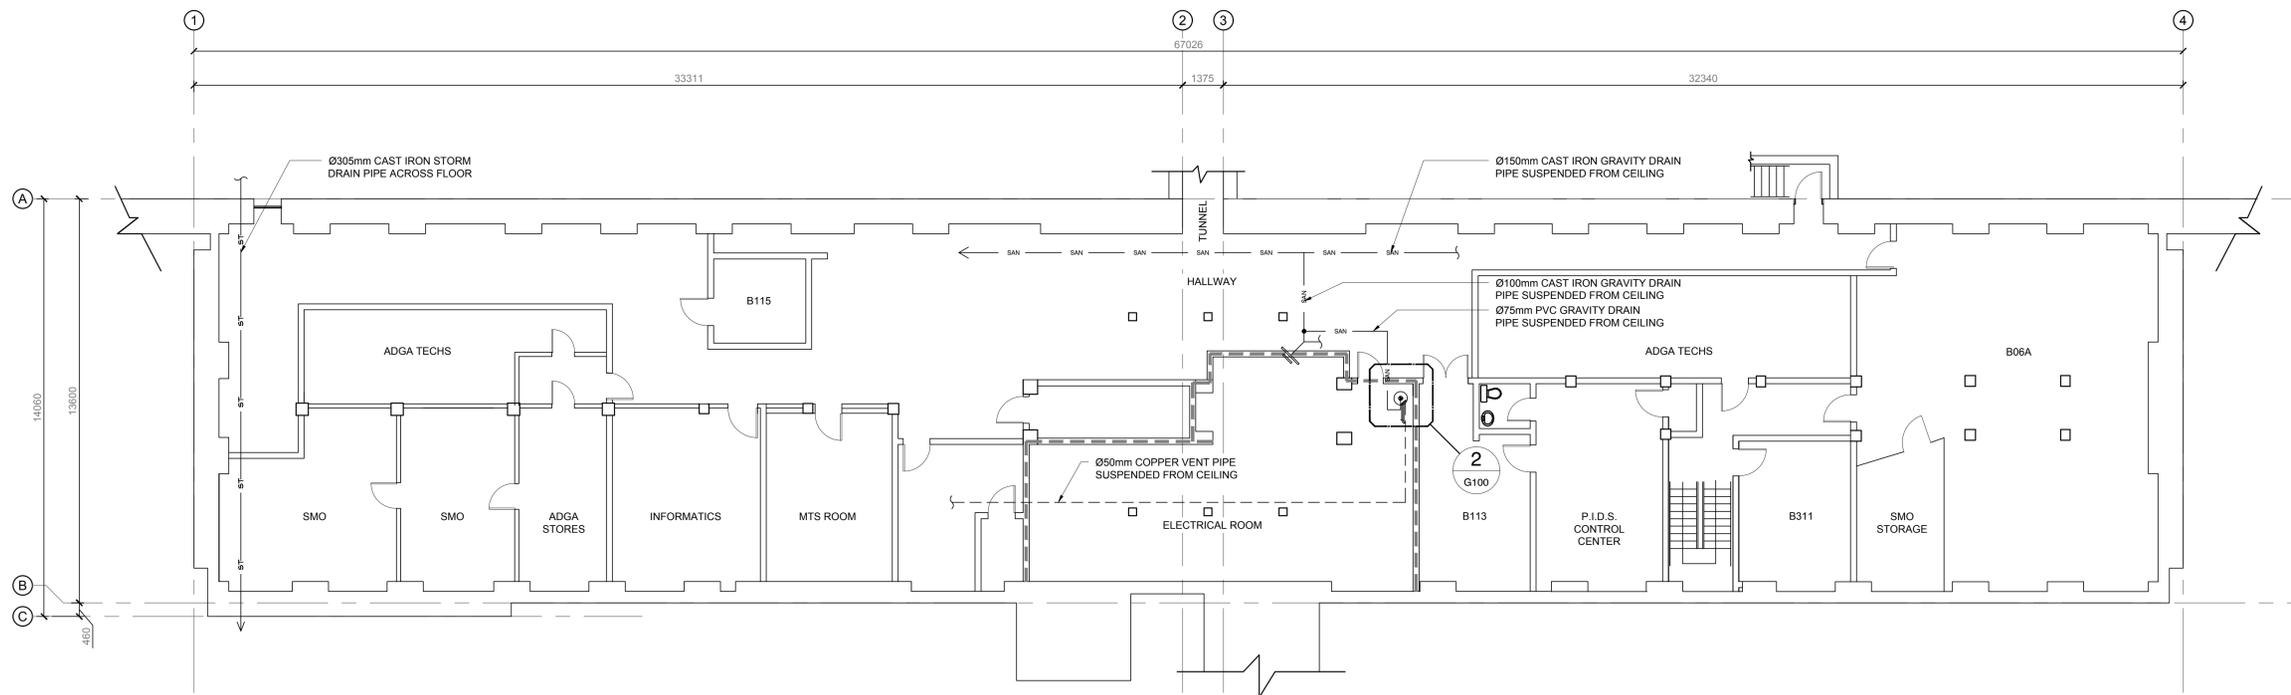


1 BASEMENT PLAN
G100 SCALE: 1:100

NOTE:
DIMENSIONS ARE APPROXIMATE ONLY.
CONTRACTOR TO VERIFY ON SITE.

LINE TYPES LEGEND		
ITEM	SYMBOL	REMARKS
SANITARY SEWER DRAIN PIPING		
SANITARY SEWER VENT PIPING		
STORM DRAIN PIPING		
FIRE RATED WALLS		1 HOUR, EXISTING

PIPING SCHEMATIC LEGEND		
ITEM	SYMBOL	REMARKS
EQUIPMENT - SEWAGE PUMP		
SANITARY SEWER CLEANOUT		

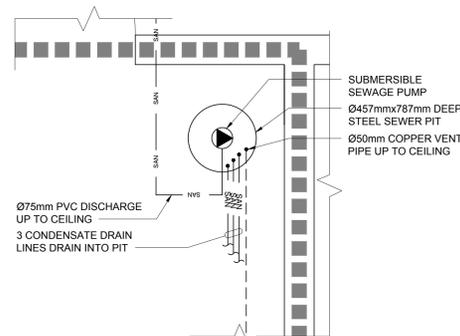

2 EXISTING SEWER PUMP/PIT PLAN
G100 SCALE: 1:20

Revision	Description	Date
5		
4	RE-ISSUED FOR TENDER (STAMPED)	2018/08/07
3	ISSUED FOR TENDER (STAMPED)	2018/05/31
2	ISSUED FOR TENDER	2018/03/29
1	99% DESIGN SUBMISSION	2018/02/21
0	50% DESIGN SUBMISSION	2017/11/23

Client: _____ client

PUBLIC WORKS & GOVERNMENT SERVICES

100-167 LOMARD AVENUE
WINNIPEG, MB. R3B 0T6

Project: CORRECTIONAL SERVICE CANADA
STONY MOUNTAIN INSTITUTION
STONY MOUNTAIN, MB

NAB STORM DRAINAGE

Designed by: MAH Conçu par

Drawn by: JF Dessiné par

Approved by: RLG Approuvé par

PWGSC Project Manager: TIM LODGE Administrateur de Projets TPSGC

Drawing Title: LOCATION PLAN, BASEMENT PLAN WITH EXISTING CONDITIONS Titre du dessin

Project no./No. du projet: R.086418.001 Drawing no./No. du dessin: G100 Revision no.: 4

1 OF 1