


- Notes:
- Do not scale drawing.
  - It is the responsibility of the appropriate Contractor to check and verify all dimensions on site and report all errors and/or omissions to the Architect or Engineer.
  - It is the responsibility of the appropriate Contractor to comply with all Codes and Regulations applicable to the performance of their work.
  - All Drawings and Specifications are instruments of service and are the property of the Architect or Engineer. This Drawing is the Copyright of STEPHENS KOZAK ACI ARCHITECTS AND PLANNERS or the Consultant named on this Drawing as at the date shown and may not be used or reproduced in whole or in part without the express written consent of the Architect or Engineer.
  - All dimensions are in mm unless noted otherwise.

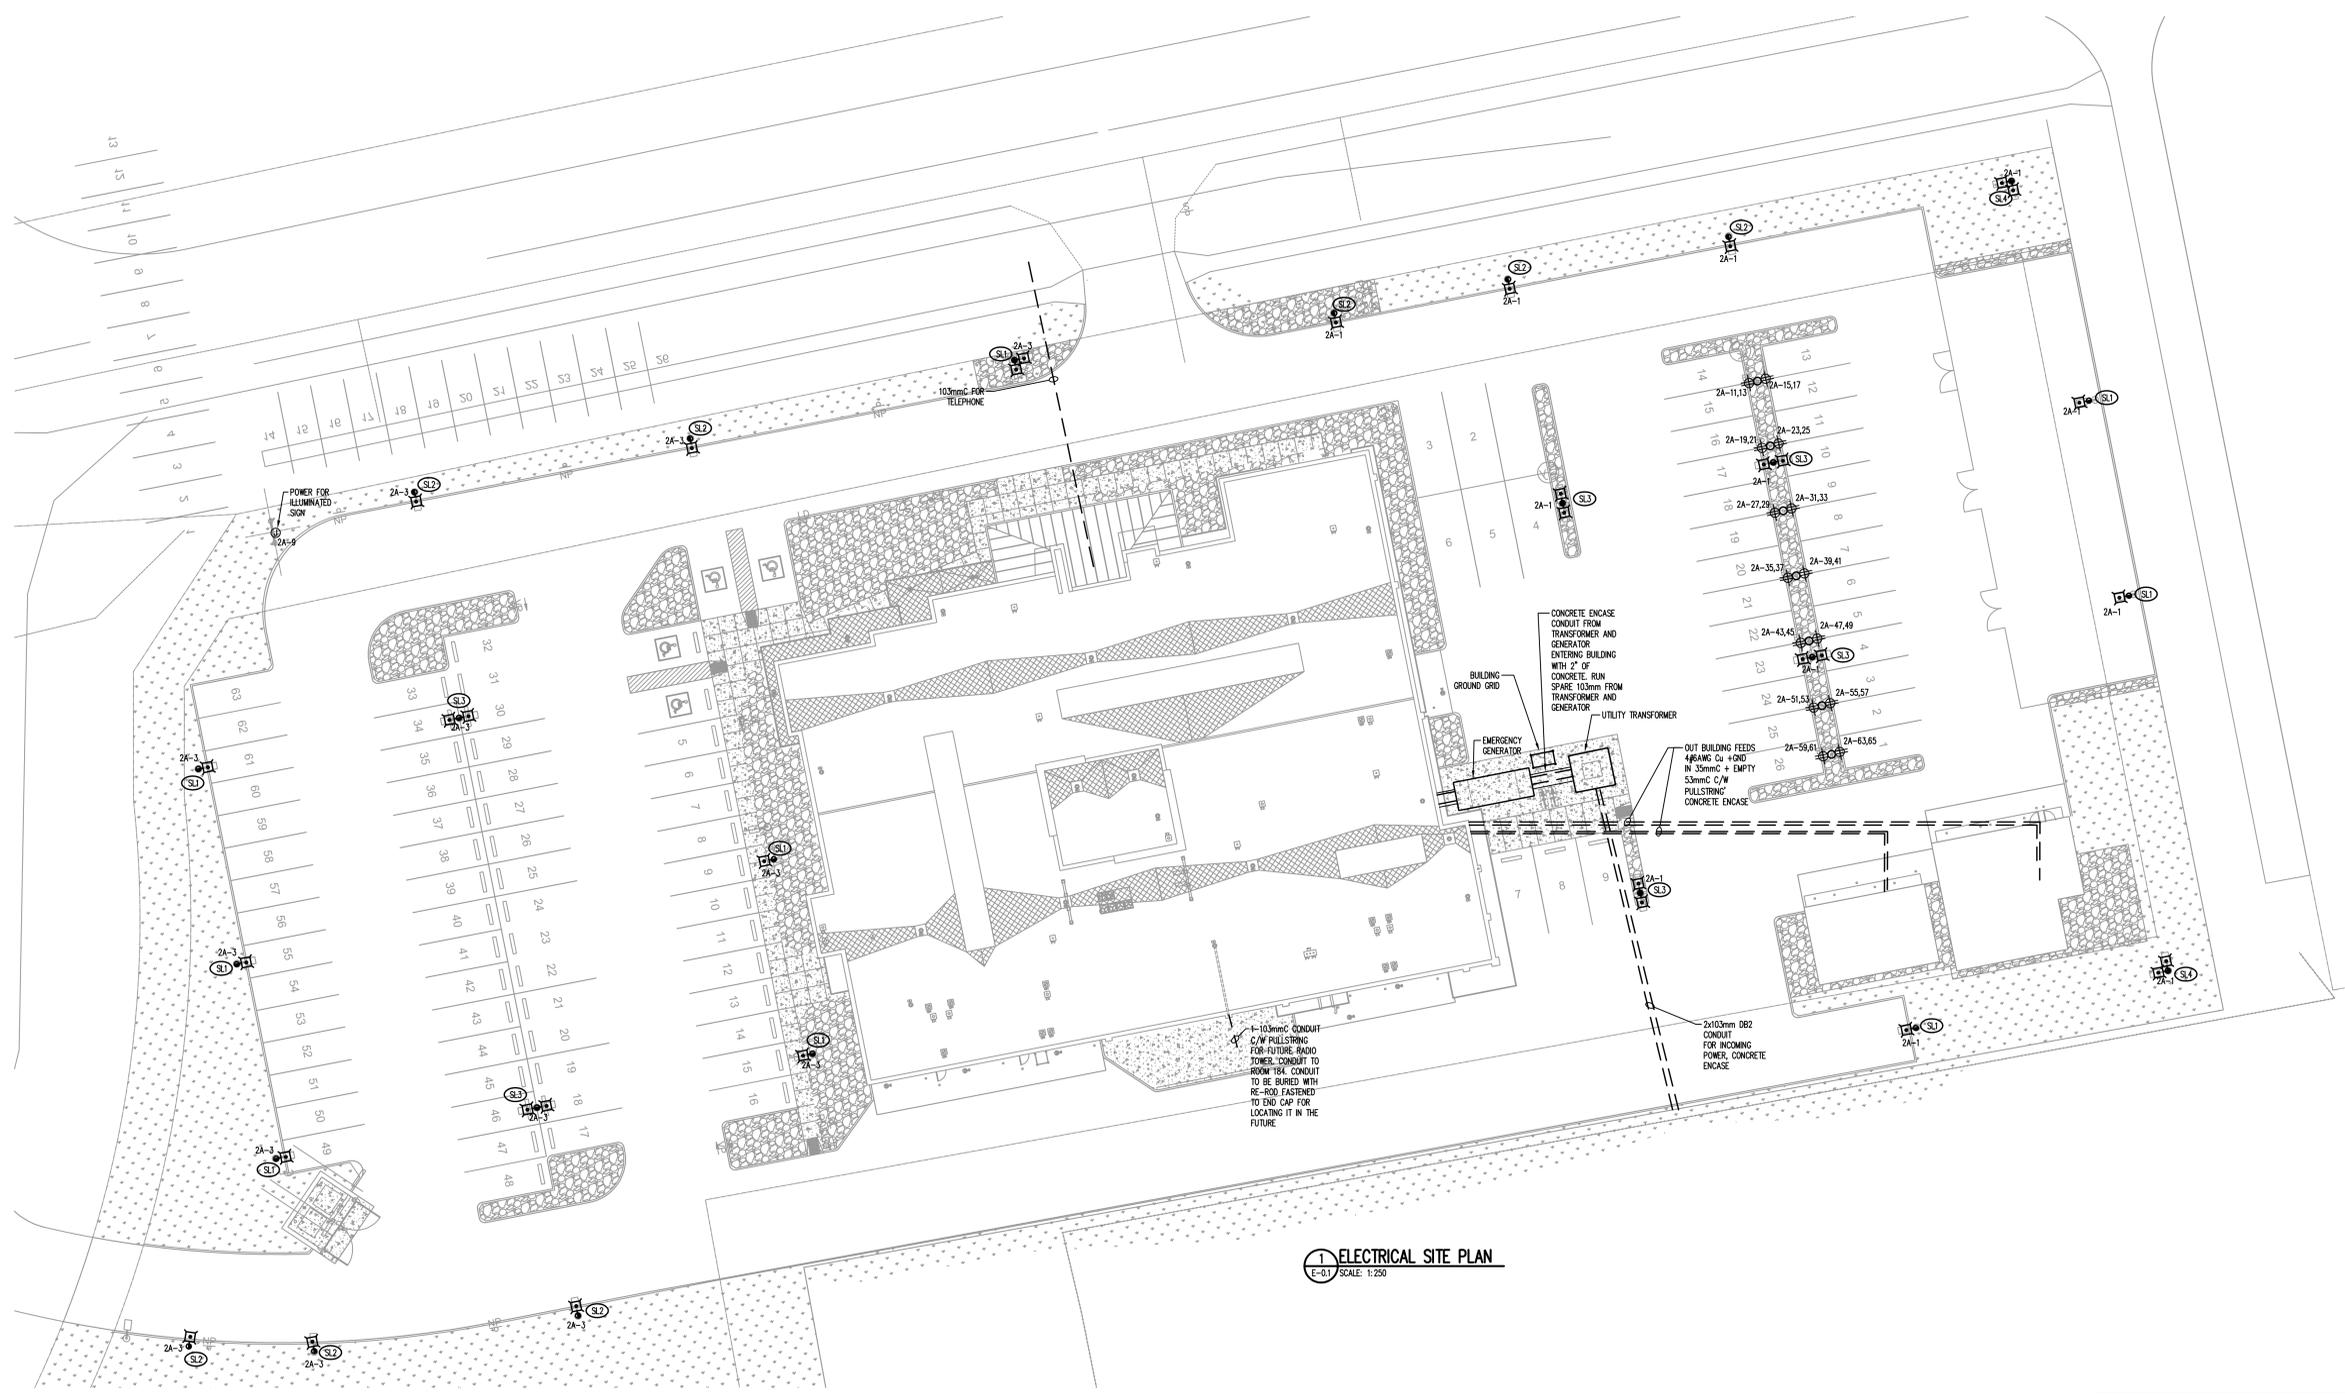

**1 ELECTRICAL SITE PLAN**  
E-01 SCALE: 1:250

**DESCRIPTION:** PREVAL AREA LIGHT  
LAMP TEMPERATURE: 3000K  
DISTRIBUTION TYPE: TYPE 4  
MOUNTING: POLE MOUNT 20 FEET  
HOUSING:  
LUMENS: 6,139  
WATTS: 57W  
SPECIAL REQUIREMENTS:

**ACCEPTABLE PRODUCTS:** FAST NUMBER  
MANUFACTURER: #1: COOPER PRV-A15-D-LNV-T4-SA-BZ 7030-HSS

**#2: ACCEPTED SUBSTITUTION**

Products are listed to establish reference standards. For acceptance of substitutions refer to General Conditions of specification.

**WE LUMINAIRE SCHEDULE** TYPE No. **SL1**

**DESCRIPTION:** PREVAL AREA LIGHT  
LAMP TEMPERATURE: 3000K  
DISTRIBUTION TYPE: TYPE 3  
MOUNTING: POLE MOUNT 20 FEET  
HOUSING:  
LUMENS: 6,139  
WATTS: 57W  
SPECIAL REQUIREMENTS:

**ACCEPTABLE PRODUCTS:** FAST NUMBER  
MANUFACTURER: #1: COOPER PRV-A15-D-LNV-T3-SA-BZ 7030-HSS

**#2: ACCEPTED SUBSTITUTION**

Products are listed to establish reference standards. For acceptance of substitutions refer to General Conditions of specification.

**WE LUMINAIRE SCHEDULE** TYPE No. **SL2**

**DESCRIPTION:** PREVAL AREA LIGHT  
LAMP TEMPERATURE: 3000K  
DISTRIBUTION TYPE: TYPE 4  
MOUNTING: POLE MOUNT 20 FEET  
HOUSING:  
LUMENS: 6,139  
WATTS: 57W  
SPECIAL REQUIREMENTS:

**ACCEPTABLE PRODUCTS:** FAST NUMBER  
MANUFACTURER: #1: COOPER PRV-A15-D-LNV-T4-SA-BZ 7030-MA1011

**#2: ACCEPTED SUBSTITUTION**

Products are listed to establish reference standards. For acceptance of substitutions refer to General Conditions of specification.

**WE LUMINAIRE SCHEDULE** TYPE No. **SL3**

**DESCRIPTION:** PREVAL AREA LIGHT  
LAMP TEMPERATURE: 3000K  
DISTRIBUTION TYPE: TYPE 4  
MOUNTING: POLE MOUNT 20 FEET  
HOUSING:  
LUMENS: 6,139  
WATTS: 57W  
SPECIAL REQUIREMENTS:

**ACCEPTABLE PRODUCTS:** FAST NUMBER  
MANUFACTURER: #1: COOPER PRV-A15-D-LNV-T4-SA-BZ 7030-MA1014

**#2: ACCEPTED SUBSTITUTION**

Products are listed to establish reference standards. For acceptance of substitutions refer to General Conditions of specification.

**WE LUMINAIRE SCHEDULE** TYPE No. **SL4**

**DESCRIPTION:** PREVAL AREA LIGHT  
LAMP TEMPERATURE: 3000K  
DISTRIBUTION TYPE: TYPE 4  
MOUNTING: WALL MOUNT AT 4000mm AFG  
HOUSING:  
LUMENS: 6,139  
WATTS: 57W  
SPECIAL REQUIREMENTS:  
NOTE THAT THE FIXTURE NEEDS TO BE SECURED TO STRUCTURAL WALL WHICH IS 10" PAST THE KNEER WALL RUN 2 1/2" WEST THROUGH WALL AND EXTEND TO ALLOW MAST OUT OF WALL

**ACCEPTABLE PRODUCTS:** FAST NUMBER  
MANUFACTURER: #1: COOPER PRV-A15-D-LNV-T4-MM-BZ 7030-PRMA-BK

**#2: ACCEPTED SUBSTITUTION**

Products are listed to establish reference standards. For acceptance of substitutions refer to General Conditions of specification.

**WE LUMINAIRE SCHEDULE** TYPE No. **SL5**

**ELECTRICAL SYMBOL LEGEND**

	BOLLARD MOUNTED PEDESTAL RECEPTACLE
	WALL MOUNTED PEDESTAL RECEPTACLE
	WALL MOUNTED LUMINAIRE
	POLE MOUNTED LUMINAIRE WITH SINGLE HEAD
	POLE MOUNTED LUMINAIRE WITH DUAL HEADS
	LUMINAIRE TAG

- GENERAL NOTES:**
- EXTERIOR LIGHTING TO BE CONTROLLED VIA PHOTOCELL ON/INTELOCK OFF.
  - CONCRETE ENCASE ALL EXTERIOR CONDUIT RUNNING UNDER DRIVE LANES.
  - THE MAJORITY OF THE FIXTURES ARE A FAIR DISTANCE AND AS SUCH THE WIRE SIZE IS TO BE UP-SIZED TO 2#AWG CU TO AVOID VOLTAGE DROP ISSUES. FOR FIXTURES WITHIN 45m OF THE ELECTRICAL ROOM 2#10 AWG CU WIRING IS ACCEPTABLE.
  - FOR EACH PARKING PEDESTAL RECEPTACLE RUN UPSIZE WIRE TO AVOID VOLTAGE DROP ISSUES. USE 2#AWG CU.
  - REFER TO CIVIL DRAWINGS FOR EXISTING UTILITY LOCATIONS. COORDINATE UTILITY CONNECTIONS WITH CIVIL DRAWINGS AND UTILITY SUPPLIERS.

PERMIT TO PRACTICE  
WILLIAMS ENGINEERING INC.  
PERMIT NUMBER  
P 10527  
The Association of Prof. Engineers  
and Geoscientists of Alberta.

EDMONTON OFFICE  
Suite 2020  
10885-102 Street  
Edmonton, AB T5A 3B1  
Fax: (780) 442-2299  
Toll Free: 1-800-262-2393  
Fax: (780) 442-1200  
Info@williamsengineering.com  
www.williamsengineering.com

WILLIAMS  
ENGINEERING  
**WE**

Issues/Revisions

No.	Description	Date	By
A	ISSUED FOR DEVELOPMENT PERMIT	2018.01.09	BR
B	ISSUED FOR 50% REVIEW	2018.03.16	BR
C	ISSUED FOR 66% REVIEW	2018.05.15	BR
D	ISSUED FOR TENDER	2019.01.09	BR




Client: Government of Canada / Gouvernement du Canada

Project: **COALDALE PROTECTIVE SERVICES BUILDING**

Scale: AS NOTED / Drawn By: [Blank]  
Project No.: 0000 / Checked By: ACI


Drawing Title: **ELECTRICAL SITE PLAN**

- Notes:
- Do not scale drawing.
  - It is the responsibility of the appropriate Contractor to check and verify all dimensions on site and report all errors and/or omissions to the Architect or Engineer.
  - It is the responsibility of the appropriate Contractor to comply with all Codes and Regulations applicable to the performance of their work.
  - All Drawings and Specifications are instruments of service and are the property of the Architect or Engineer. This Drawing is the Copyright of STEPHENS KOZAK ACI ARCHITECTS AND PLANNERS or the Consultant named on this Drawing as at the date shown and may not be used or reproduced in whole or in part without the express written consent of the Architect or Engineer.
  - All dimensions are in mm unless noted otherwise.

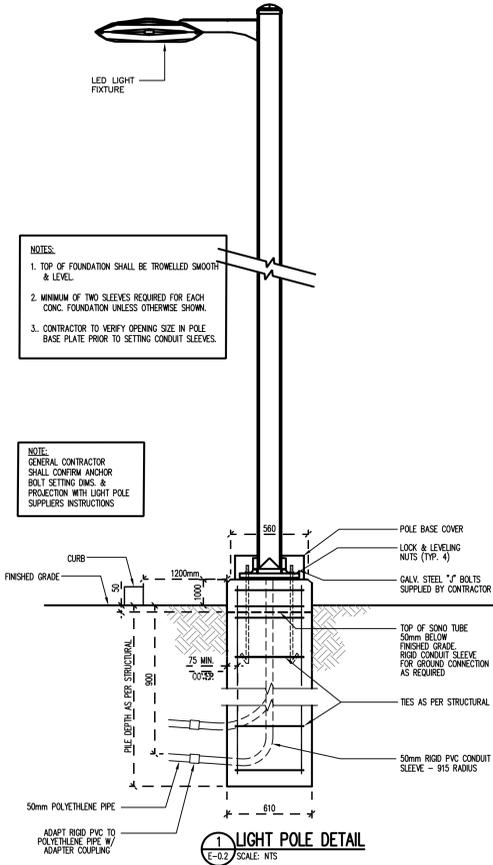


- NOTES:
- TOP OF FOUNDATION SHALL BE TROWELLED SMOOTH & LEVEL.
  - MINIMUM OF TWO SLEEVES REQUIRED FOR EACH CONC. FOUNDATION UNLESS OTHERWISE SHOWN.
  - CONTRACTOR TO VERIFY OPENING SIZE IN POLE BASE PLATE PRIOR TO SETTING CONDUIT SLEEVES.

NOTE:  
GENERAL CONTRACTOR SHALL CONFIRM ANCHOR BOLT SETTING DIMS. & PROJECTION WITH LIGHT POLE SUPPLIER'S INSTRUCTIONS

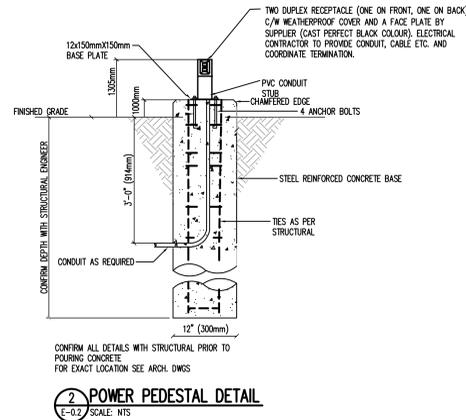


CONFIRM ALL DETAILS WITH STRUCTURAL PRIOR TO POURING CONCRETE FOR EXACT LOCATION SEE ARCH. DWGS

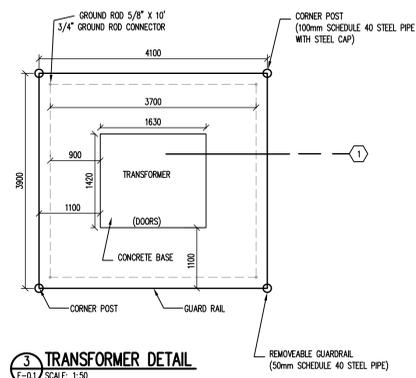

NOTE: REFER TO FORTIS CONNECTION GUIDE FOR PARTICULAR SERVICE DETAILS.

- DETAIL 1 KEYNOTES:
- HIGH VOLTAGE 103mm CONDUIT RIGID PVC.

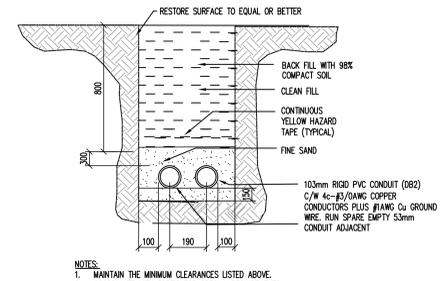

- NOTES:
- MAINTAIN THE MINIMUM CLEARANCES LISTED ABOVE.
  - COORDINATE WITH FORTIS FOR SPECIAL REQUIREMENTS.
  - CLEARANCE OF 500mm WHEN ABOVE WATER LINE, 300mm WHEN BELOW WATER LINE AND 1800mm HORIZONTAL OF WATER LINE.
  - CLEARANCE OF 1000mm HORIZONTAL AND 300mm VERTICAL FOR GAS LINE.
  - CLEARANCE OF 1000mm WHEN PARALLEL TO ANY UTILITY LINE.
  - CLEARANCE OF 3000mm FROM VALVE, DRAINAGE MAN HOLE OR STORM LINE.
  - CLEARANCE OF 3000mm FROM CENTRE OF ANY HYDRANT. PRIMARY CABLE SHOULD BE ENCASED IN CONCRETE WHEN IN AREA CONTAINING A HYDRANT.
  - CONCRETE ENCASE CONDUIT UNDER ROADWAYS.

PERMIT TO PRACTICE  
WILLIAMS ENGINEERING CANADA INC.  
PERMIT NUMBER  
P 10527  
The Association of Prof. Engineers  
and Geoscientists of Alberta.

EDMONTON OFFICE  
Suite 4020  
10885-102 Street  
Edmonton, AB T5A 3B1  
Box 1910, 044-2033  
Toll Free: 1-877-243-2393  
Fax: 780-452-1200  
Info@williamseng.com  
www.williamseng.com

WILLIAMS  
ENGINEERING  
WE

Issues/Revisions

No.	Description	Date	By
A	ISSUED FOR DEVELOPMENT PERMIT	2018.01.09	BR
B	ISSUED FOR 50% REVIEW	2018.03.16	BR
C	ISSUED FOR 66% REVIEW	2018.05.15	BR
D	ISSUED FOR TENDER	2019.01.09	BR



Client  
Government of Canada / Gouvernement du Canada



Project  
**COALDALE PROTECTIVE SERVICES BUILDING**

Scale	AS NOTED	Designed By
Project No.	0000	Drawn By
Date	2001 JANUARY 00	Checked By ACI

Drawing Title  
**ELECTRICAL SITE DETAILS**

Drawing No.  
**E-0.2**

Notes:

- Do not scale drawing
- It is the responsibility of the appropriate Contractor to check and verify all dimensions on site and report all errors and/or omissions to the Architect or Engineer
- It is the responsibility of the appropriate Contractor to comply with all Codes and Regulations applicable to the performance of their work.
- All Drawings and Specifications are instruments of service and are the property of the Architect or Engineer. This Drawing is the Copyright of STEPHENS KOZAK ACI ARCHITECTS AND PLANNERS or the Consultant named on this Drawing as at the date shown and may not be used or reproduced in whole or in part without the express written consent of the Architect or Engineer.
- All dimensions are in mm unless noted otherwise.

ELECTRICAL SYMBOL LEGEND	
	DUPLEX RECEPTACLE DESCRIPTORS: c = MOUNTED ABOVE COUNTER GFI = GROUND FAULT INTERRUPTER WP = WEATHER PROOF u/c = UNDER COUNTER T = 20A TSLT RECEPTACLE
	QUAD RECEPTACLE
	SPECIAL RECEPTACLE; SEE DRAWING NOTES
	CEILING MOUNTED DUPLEX RECEPTACLE
	JUNCTION BOX
	MOTOR CONNECTION
	MOTOR EQUIPMENT DISCONNECT
	CARD READER
	KEYSWITCH
	PUSHBUTTON P = PANIC BUTTON
	ELECTRIC STRIKE
	MOTION DETECTOR
	KEYPAD ROUGH-IN
	DOOR POSITION SWITCH
	MICROPHONE OUTLET
	TV OUTLET
	CCVE OUTLET
	VOICE/DATA OUTLET, #/FT INDICATES CAT5A DATA DROPS
	DURESS ALARM HORN

**KEYNOTES:**

- WALL BOX ABOVE COUNTER TO JUNCTION BOX ABOVE CEILING HOME RUN TO ROOM 184 FOR CCVE MICROPHONE.
- CCVE-CONDUIT C/W DATE HOME RUN TO ROOM 184. TERMINATE AND TEST CABLE AT BOTH ENDS. IN ROOMS 114-129, SHALL HAVE A SECURITY CALK AT JOINT TO WALL/CEILING.
- MICROPHONE OUTLET-HOME RUN TO ROOM 109. MICROPHONE CABLE TO BE SHIELDED 2 PAR/24 GAUGE.
- CCVE MONITORS HOME RUN TO ROOM 184 (5 MONITORS AND RUNS). REFER TO ARCHITECTURAL ELEVATION 3/A6.2 FOR DETAIL OF MOUNTING.
- RETRACTABLE CORD REEL.
- RECEPTACLE IS TO BE RECESSED INTO THE WALL.
- SYSTEMS FURNITURE. PROVIDE CONNECTION INTO FURNITURE. FURNITURE INSTALLER IS TO PROVIDE PAC POLES. PAC POLES ARE TO BE USED TO ACCOMMODATE BOTH POWER AND DATA REQUIREMENTS AS SHOWN.
- RUN A 53mm EMT CONDUIT CAPPED WITH A WEATHERPROOF JUNCTION BOX AT THE EXTERIOR WALL AT 10 FT TO THE ROOM 184. PROVIDE A JUNCTION BOX FOR THE 53mm CONDUIT IN THE ROOM 184. LABEL AS "EXT".
- PROVIDE ACOUSTIC PUTTY WITHIN OUTLETS AS WELL AS PLASTIC VAPOUR BARRIER. ENSURE THAT THE OUTLET SHARES THE SAME STUD SPACE. GROUT BEHIND BOXES IN CONCRETE FLOOR WALLS.
- CCVE AND MICROPHONE TO HOME RUN ROOM 109. CCVE CABLE TO BE CAT5A. MICROPHONE CABLE TO BE SHIELDED 2 PAR/24 GAUGE.
- PROVIDE A 27mm EMT CONDUIT FROM ROOM 109 BACK TO THE ROOM 184 C/W PULLSTRING FOR FUTURE USE.
- PUSHBUTTON TO RELEASE ELECTRIC STRIKE ON ROOM 172. THE DOOR RELEASE IS NOT REQUIRED TO BE PART OF THE OVERALL SECURITY SYSTEM AND CAN BE STAND ALONE FOR THE OPERATOR AT THE LOCATION SHOWN.
- PANIC DURESS ALARM. PROVIDE 27mm CONDUIT C/W PULL STRING FROM PANIC/DURESS ALARM WITH SOUNDING DEVICE. RESET BUTTON LOCATIONS SHOWN.
- RUN #2/DWG CU FROM MAIN GROUNDING BUS BAR TO THE MAIN TELECOM BUS BAR.
- R INDICATES A DATA OUTLET FOR RADIO REMOTE. DATA CABLE IN CONDUIT WILL HOME RUN TO ROOM 184 RADIO SWITCH. PROVIDE LABEL INDICATING OUTLET IS FOR RADIO.
- RUN A 53mm EMT CONDUIT TO ROOM 142 FOR FUTURE CAR VIDEO SYSTEM.
- USE CHASE TO RUN ELECTRICAL OVER CLOSETORY AREA.
- PROVIDE AN EMPTY 50mm CONDUIT BETWEEN THE FLOORBOX AND THE WALL FOR FUTURE AV CONNECTIONS.
- PROVIDE CT41 SECURITY PHONE AT +1050mmAFF FOR ROOM 131. PHONE TO BE ANALOG NOT VOP.
- SUPPLY POWER TO MECHANICAL CONTROL PANEL. EXACT LOCATION AS PER MECHANICAL PLANS.
- RUN A 103mm CONDUIT C/W PULLSTRING TO THE RADIO RACK IN ROOM 184 HIGH ON WALL.
- RUN 2-103mm CONDUIT C/W PULLSTRING BETWEEN THE ROOF OF ROOM 182 AND THE RACK IN ROOM 184. PROVIDE WEATHER TIGHT GUSSETERS AT THE ROOF OF THE CONDUITS. ONE CONDUIT IS TO BE RUN AT OPPOSITE ENDS OF THE ROOF.
- AT THE DEMARK POINT BRING 100 PAIR CABLE FROM THE DEMARK TO THE RACKS. 50 PAIRS OF VOICE AND 50 PAIRS OF DATA.
- PROVIDE ACR-41 SECURITY PHONE AT +1050mmAFF FOR EXTERIOR HELP. PHONE TO BE ANALOG NOT VOP.
- RUN A 53mm CONDUIT TO 114 C/W PULLSTRING FOR FUTURE PAT SYSTEM BACK TO ROOM 184.
- FUTURE PERIMETER CAMERA JUNCTION BOX MOUNT IN PLENUM SPACE AT +4400mm OR HIGHER. RUN CONDUIT JUST BELOW ROOF DECK OR WITHIN DECK FLUTES IF POSSIBLE. SUPPLY AND INSTALL A 4X4 JUNCTION BOX C/W 1" CONDUIT PIPED BACK TO CCVE RACK IN LAN ROOM 184.
- VARIABLE SPEED FAN CONTROL SINK FOR METSINK. PROVIDE ADJUSTABLE MOTOR SPEED CONTROL UNIT SO THAT WHEN IN USE THE FAN SPEED IS INCREASED AND WHEN NOT IN USE, THE SPEED IS REDUCED. THE FAN IS TO RUN AT ALL TIMES JUST AT DIFFERENT SPEEDS IF IN USE OR NOT.
- SUPPLY AND INSTALL A 53mm CONDUIT FROM ROOM 184 TO A JUNCTION BOX WITH A COVERPLATE MOUNTED IN THE CEILING SPACE OF ROOM 100 FOR FUTURE ALARM

**GENERAL NOTES:**

- NOTE THAT THE DOOR ACCESS CONTROL, CCVE AND MICROPHONE LOCATIONS WITH HOME RUNS ARE CONDUIT ROUGH-IN ONLY AND ARE TO BE REFERRED TO AS THE SECURITY ROUGH-INS.
- PROVIDE 27mm CONDUIT C/W PULL STRING FOR ALL MICROPHONE CABLE TO CEILING 2 PAR/24 GAUGE. DRAWINGS AND DETAILS. ALL BOXES SHALL HAVE ACOUSTIC INSULATION, PUTTY AND CAULKING TO ATTAIN REQUIRED STC RATING.
- NO EXPOSED CONDUITS ARE PERMITTED. ALL CONDUITS ARE TO BE RUN WITHIN THE WALLS.
- COMBINE POWER AND DATA INTO SINGLE OUTLET BOXES WHERE POSSIBLE. IN ACOUSTIC WALLS THIS IS NECESSARY SO DEVICES AREN'T EXTENSIVELY SPACED OUT BETWEEN EACH OTHER.
- PROVIDE REPERFORATING FIRE STOPPING MATERIAL FOR CONDUIT PENETRATIONS INTO ROOMS 142 AND 184. FIRE STOP SYSTEMS USED FOR DATA AND COMMUNICATION CABLES THROUGH RATED AND NON-RATED FIRE SEPARATIONS SHALL BE RE-PERFORABLE DESIGNS WHICH ALLOW FOR NEW CABLES TO BE PULLED WITHOUT HAVING TO RE-INSTALL NEW FIRE STOP MATERIALS.
- MOUNT ALL KEYSWITCHES AT +1200mmAFF ON CENTER.
- THERE ARE TO BE 3 DISTINCT ALARMS FOR THE PANIC DURESS ALARM. ONE FOR ROOMS 130/114, ONE FOR ROOMS 178, 183, 157, 136, 145, 146, 147, 188, 189 AND 184. WHEN THE USER ENTERS THE ROOM THE MOTION SENSOR IS TO BE TRIGGERED AND THE ALARM IS TO BEGIN CHIRPING UNTIL A CODE IS RECEIVED. DISARMING THE SYSTEM THERE IS TO BE A 1-MINUTE WARNING PERIOD. THIS IS TO BE THE SAME UPON EXITING THE ROOM. A CODE IS ENTERED, ARMING THE SYSTEM, FOLLOWED BY A 1-MINUTE PERIOD FOR THE USER TO VACATE THE ROOM AND CLOSE THE DOOR.

PERMIT TO PRACTICE  
WILLIAMS ENGINEERING INC.  
PERMIT NUMBER  
P 10527  
The Association of Prof. Engineers  
and Geoscientists of Alberta.

EDMONTON OFFICE  
Suite 620  
1000-102 Street  
Edmonton, AB T5G 2B1  
Tel: (780) 462-2292  
Fax: (780) 462-2293  
www.williamsengineering.com

WILLIAMS ENGINEERING  
WE

Issues/Revisions			
No.	Description	Date	By
A	ISSUED FOR 50% REVIEW	2018.03.16	BR
B	ISSUED FOR 66% REVIEW	2018.05.15	BR
C	ISSUED FOR 75% REVIEW	2018.06.25	BR
D	ISSUED FOR TENDER	2019.01.09	BR



Client: Government of Canada / Gouvernement du Canada

Canada


Project: **COALDALE PROTECTIVE SERVICES BUILDING**

Scale: AS NOTED	Designed By: BR
Project No.: 0000	Drawn By: BR
Date: 2001 JANUARY 00	Checked By: MF


Drawing Title: **ELECTRICAL POWER, DATA & SECURITY PLAN**

Drawing No.

**E2.0**

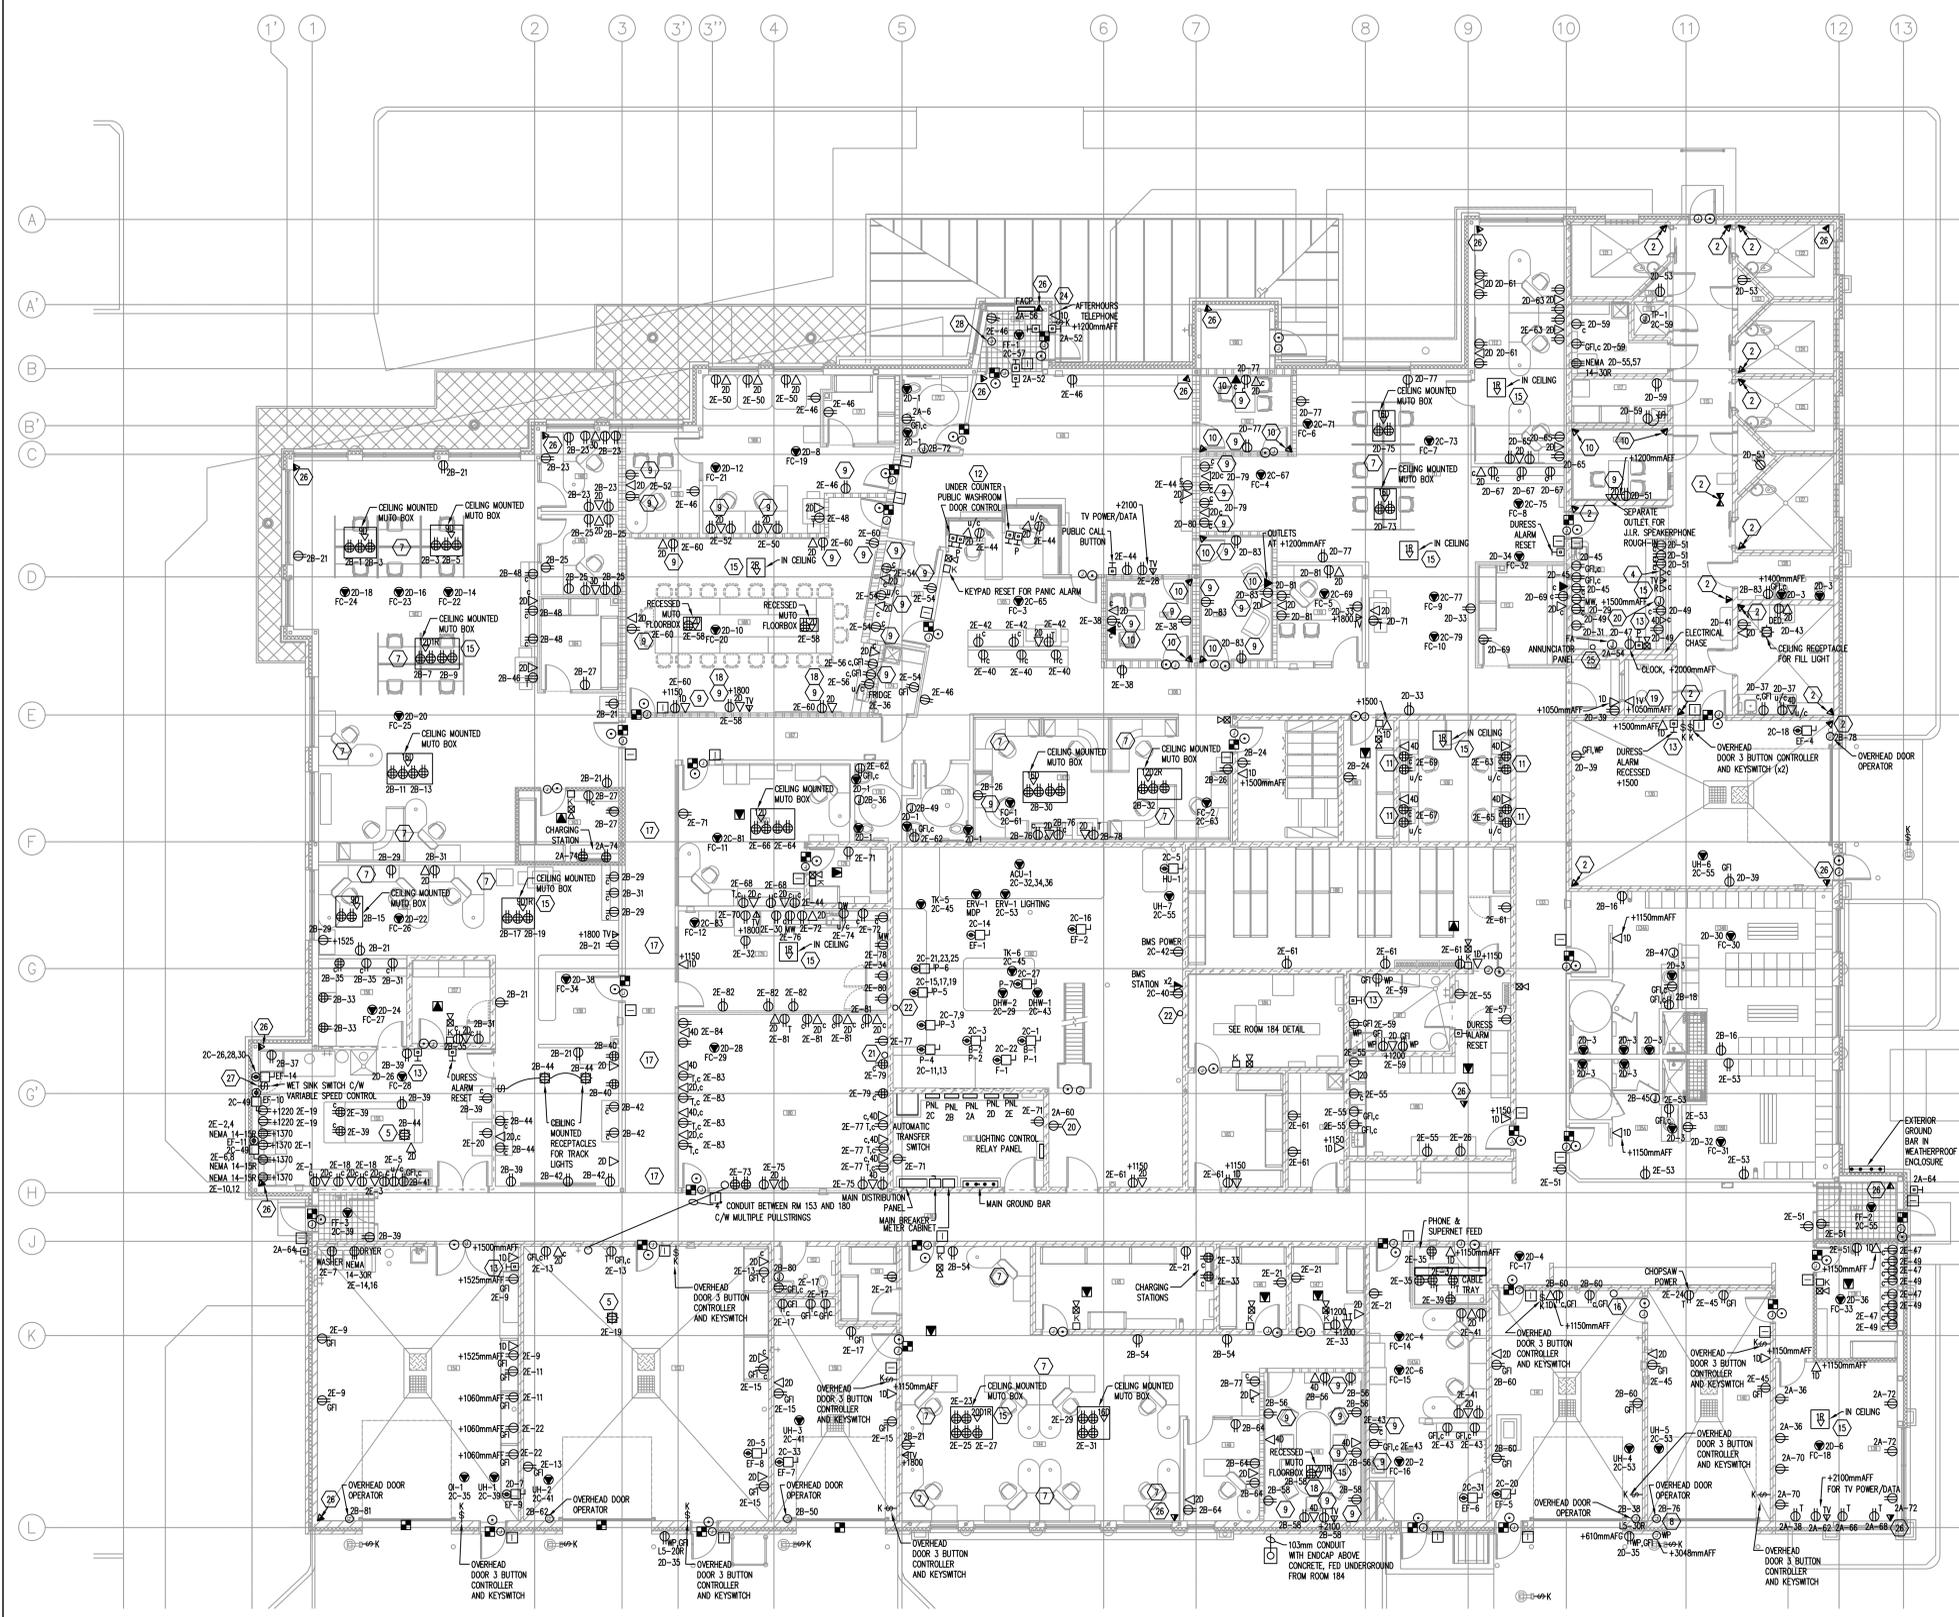

**1 POWER, DATA & SECURITY PLAN**  
E2.0 SCALE: 1:50

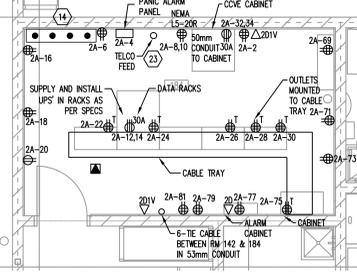

**2 RM 184 DETAIL**  
E2.0 SCALE: 1:50

Notes:

- Do not scale drawing
- It is the responsibility of the appropriate Contractor to check and verify all dimensions on site and report all errors and/or omissions to the Architect or Engineer
- It is the responsibility of the appropriate Contractor to comply with all Codes and Regulations applicable to the performance of their work.
- All Drawings and Specifications are instruments of service and are the property of the Architect or Engineer. This Drawing is the Copyright of STEPHENS KOZAK ACI ARCHITECTS AND PLANNERS or the Consultant named on this Drawing as at the date shown and may not be used or reproduced in whole or in part without the express written consent of the Architect or Engineer.
- All dimensions are in mm unless noted otherwise.

ELECTRICAL SYMBOL LEGEND	
	DUPLEX RECEPTACLE DESCRIPTORS: C = MOUNTED ABOVE COUNTER GFI = GROUND FAULT INTERRUPTER MP = WEATHER PROOF u/c = UNDER COUNTER T = TOILET RECEPTACLE
	QUAD RECEPTACLE
	SPECIAL RECEPTACLE, SEE DRAWING NOTES
	CEILING MOUNTED DUPLEX RECEPTACLE
	JUNCTION BOX
	MOTOR CONNECTION
	MOTOR EQUIPMENT DISCONNECT
	CARD READER
	KEY SWITCH
	PUSHBUTTON-DOOR OPERATOR P = PANGIC BUTTON
	ELECTRIC LOCKSET
	MOTION DETECTOR
	KEYPAD ROUGH-IN
	MICROPHONE OUTLET
	TV OUTLET
	OCV OUTLET
	VOICE/DATA OUTLET, #D/#T INDICATES CAT6A DATA DROPS
	MANUAL PULLSTATION
	HORN/STROBE COMBO
	STROBE
	HEAT DETECTOR H = HIGH TEMPERATURE L = LOW TEMPERATURE R = RATE OF RISE
	SMOKE DETECTOR CS = SECURE CAGE AROUND DETECTOR
	CEILING MOUNT EXIT SIGN
	WALL MOUNT EXIT SIGN
	RECESSED LUMINAIRE
	SURFACE OR PENDANT LUMINAIRE
	LUMINAIRE, FLUORESCENT, UNSWITCHED (NIGHT LIGHT)
	WALL MOUNTED LUMINAIRE
	RECESSED DOWNLIGHT
	WALL MOUNTED LUMINAIRE
	LUMINAIRE TAG
	SWITCH, SINGLE-POLE: D = DIMMER SWITCH 3 = 3-WAY SWITCH YS = VACANCY SENSOR
	CEILING MOUNTED OCCUPANCY SENSOR PIR = PASSIVE INFRARED POT = PASSIVE DUAL TECHNOLOGY

PERMIT TO PRACTICE  
WILLIAMS ENGINEERING CANADA INC.  
PERMIT NUMBER  
P 10527  
The Association of Prof. Engineers  
and Geoscientists of Alberta.

EDMONTON OFFICE  
Suite 202  
10805-102 Street  
Edmonton, AB T5J 3B1  
Box 780, 444-2200  
Toll Free: 1-800-263-2393  
Fax: 780-454-1200  
Info@williamseng.com  
www.williamseng.com

WILLIAMS  
ENGINEERING  
WE

Issues/Revisions

No.	Description	Date	By
A	ISSUED FOR 50% REVIEW	2018.03.16	BR
B	ISSUED FOR 66% REVIEW	2018.05.15	BR
C	ISSUED FOR 75% REVIEW	2018.06.26	BR
D	ISSUED FOR TENDER	2019.01.09	BR



Client  
 Government of Canada / Gouvernement du Canada

Project  
**Canada**


COALDALE PROTECTIVE SERVICES BUILDING

Scale	AS NOTED	Designed By	BR
Project No.	0000	Drawn By	BR
Date	2001 JANUARY 00	Checked By	MF

Drawing Title  
**ROOF PLAN & OUTBUILDINGS ELECTRICAL PLANS**

Drawing No.

**E2.1**

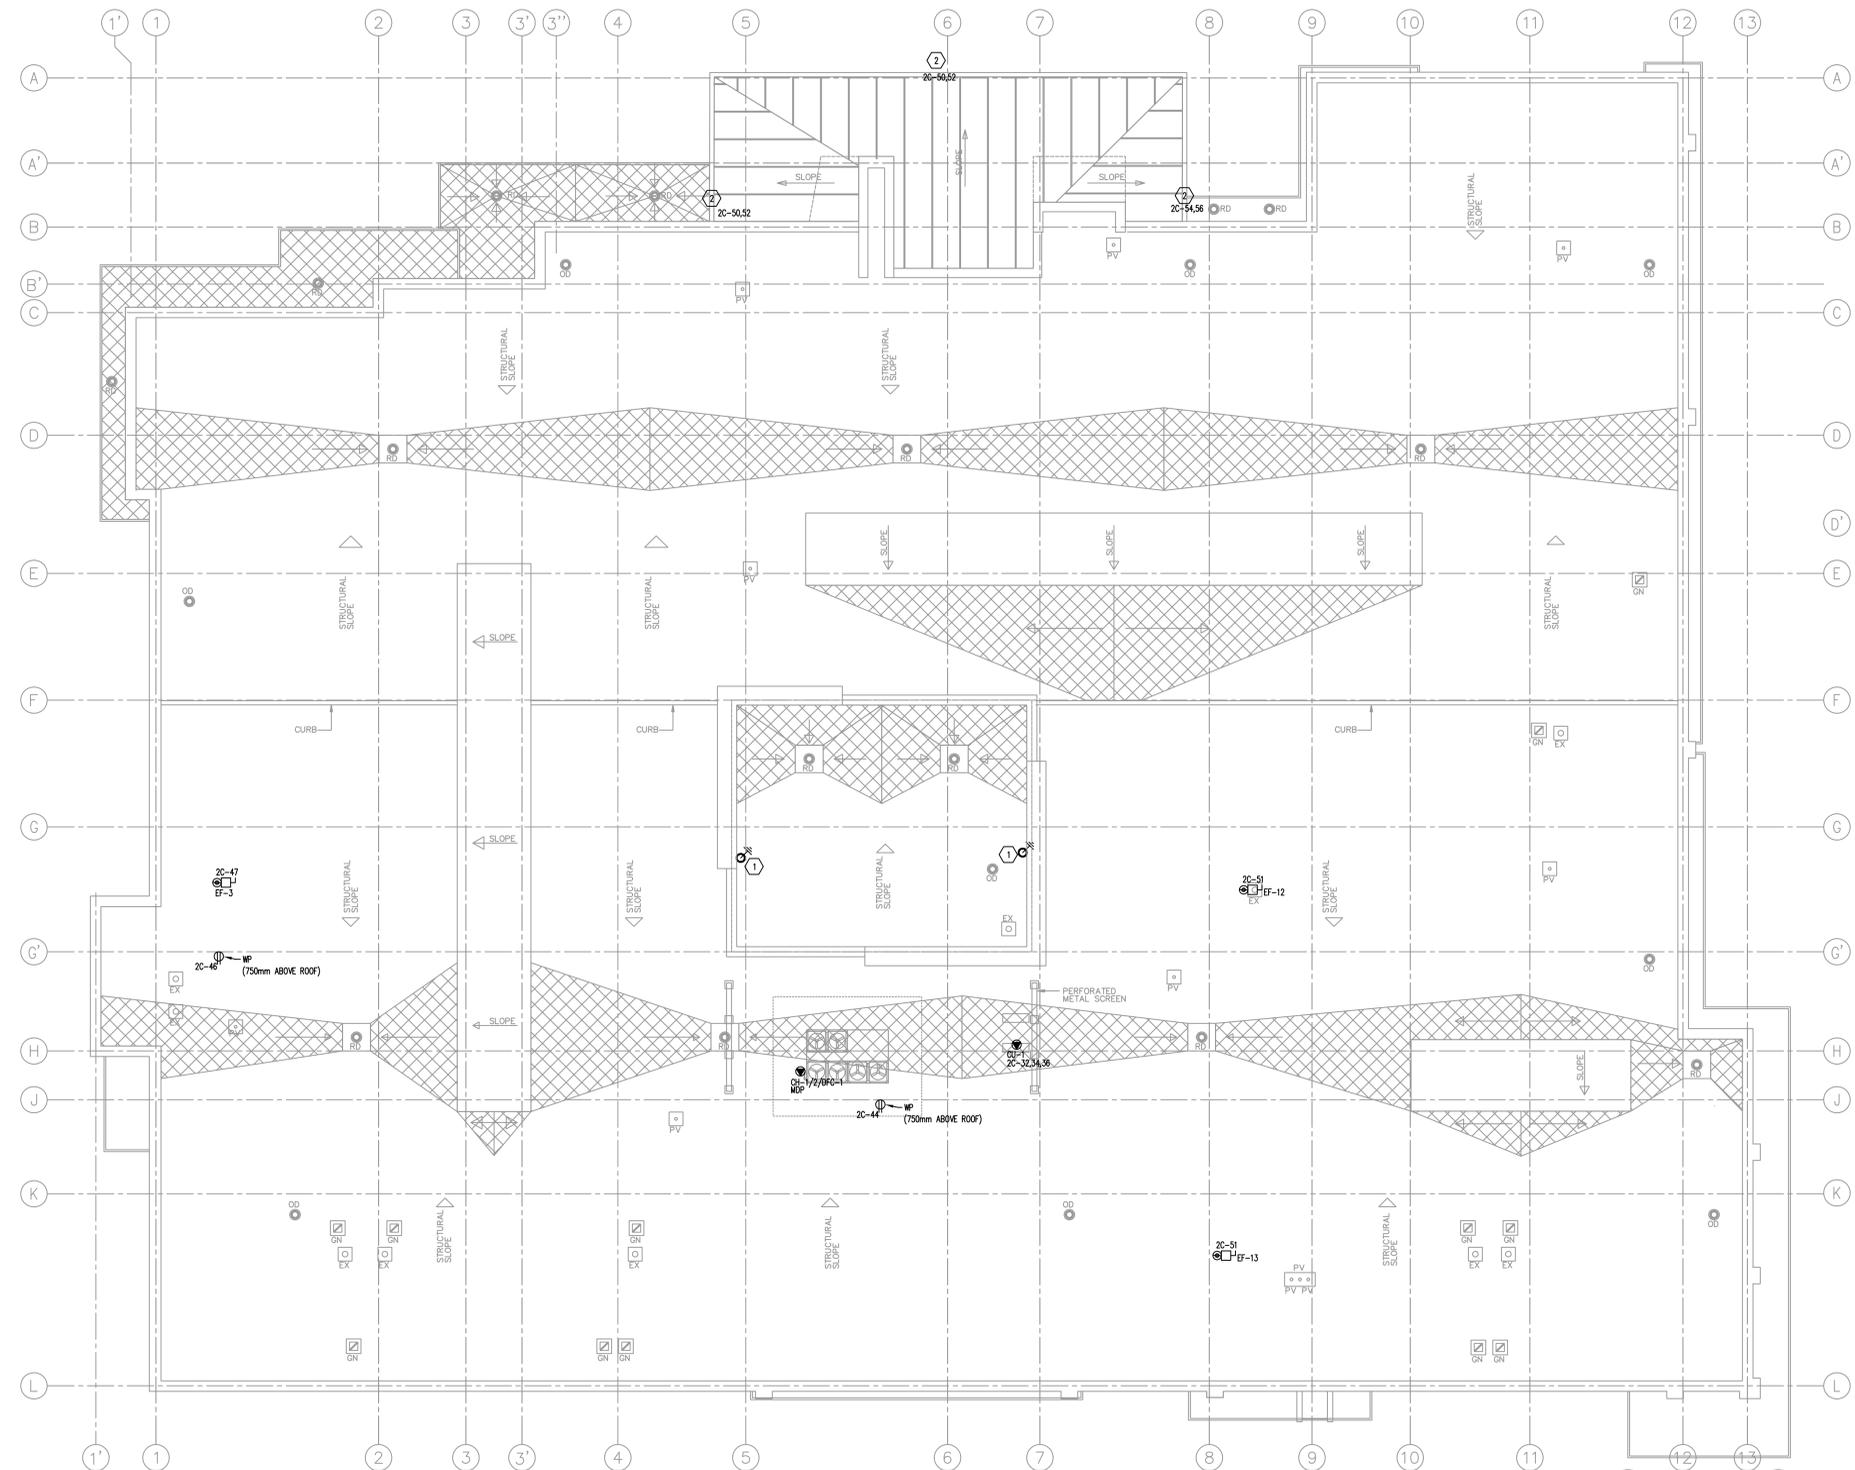

**KEYNOTES:**

- CONTRACTOR TO SUPPLY 102mm CONDUITS FROM THE ANTENNA MAST TO ROOM 184. PROVIDE WEATHER TIGHT GOOSENECKS AT ROOF END OF CONDUITS. ANTENNAE TO BE SUPPLIED AND INSTALLED BY OWNER.
- HEAT TRACE DOWNSLOPE OFF OF CANOPY. COORDINATE EXACT LOCATION WITH ARCHITECTURAL. USE 8W/FT HEAT TRACING.


**1 ROOF POWER PLAN**  
SCALE: 1:100

**GENERAL NOTES:**

- DOOR POSITION SWITCH TO RUN BACK TO SECURITY PANEL IN ROOM 184.

**KEYNOTES:**

- FUTURE PERIMETER CAMERA JUNCTION BOX. SUPPLY AND INSTALL A 4X4 JUNCTION BOX C/W 1" CONDUIT PIPED BACK TO OCV RACK IN LAN ROOM 184.

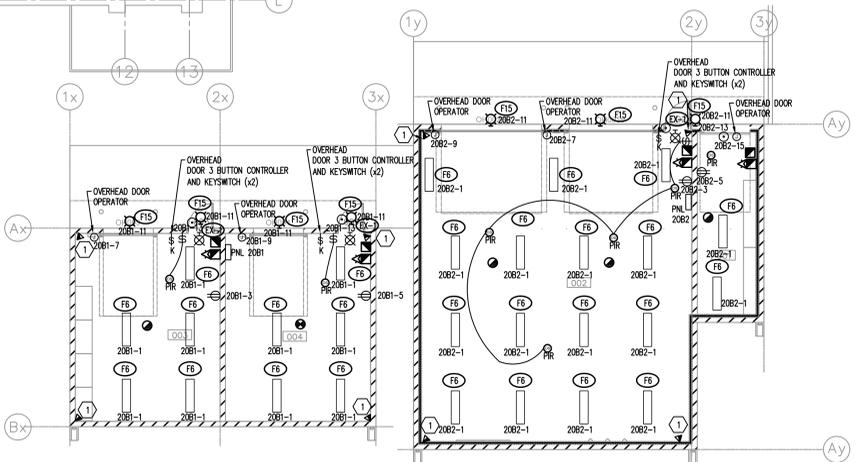

**2 POWER, DATA & SECURITY OUTBUILDING PLANS**  
SCALE: 1:100

Notes:

- Do not scale drawing
- It is the responsibility of the appropriate Contractor to check and verify all dimensions on site and report all errors and/or omissions to the Architect or Engineer
- It is the responsibility of the appropriate Contractor to comply with all Codes and Regulations applicable to the performance of their work.
- All Drawings and Specifications are instruments of service and are the property of the Architect or Engineer. This Drawing is the Copyright of STEPHENS KOZAK ACI ARCHITECTS AND PLANNERS or the Consultant named on this Drawing as at the date shown and may not be used or reproduced in whole or in part without the express written consent of the Architect or Engineer.
- All dimensions are in mm unless noted otherwise.

**ELECTRICAL SYMBOL LEGEND**


	RECESSED LUMINAIRE
	SURFACE OR PENDANT LUMINAIRE
	LUMINAIRE, FLUORESCENT, UNSWITCHED (NIGHT LIGHT)
	WALL MOUNTED LUMINAIRE
	RECESSED DOWNLIGHT
	WALL MOUNTED LUMINAIRE
	LUMINAIRE TAG
	SWITCH, SINGLE-POLE: D = DIMMER SWITCH 3 = 3-WAY SWITCH VS = VACANCY SENSOR
	CEILING MOUNTED OCCUPANCY SENSOR PIR = PASSIVE INFRARED PDT = PASSIVE DUAL TECHNOLOGY
	EMERGENCY BATTERY BACKUP IN FIXTURE

**KEYNOTES:**

- 3 POSITION SWITCH FOR CELL LIGHTS
- LINE VOLTAGE SWITCH WITH BUILT IN OCCUPANCY SENSOR.
- IN USE LIGHT TO BE KEELLESS SOCKET C/W RED LAMP CONNECTED TO INTERIOR SWITCH.
- IN USE LIGHT TO BE KEELLESS SOCKET C/W RED LAMP AND WEATHERPROOF COVER CONNECTED TO INTERIOR SWITCH.
- BATTERY PACK BP-1 TO BE EQUAL TO AMULTE EBST-12-036-2MP-5WLA-WIT.

**GENERAL NOTES:**

- FACILITY HAS A 1000 KW RATED GENERATOR FOR COMPLETE BUILDING LOAD FOR 24 HOURS. ALL LIGHTING IS CONNECTED TO THIS GENERATOR AND WILL ACT AS EMERGENCY LIGHTING IN THE CASE OF POWER FAILURE. SOME INDIVIDUAL FIXTURES TAGGED WITH 'EM' ARE TO INCLUDE BUILT IN BATTERY BACKUP IN CASE OF INDIVIDUAL CIRCUIT FAILURE.
- SWITCHES SHOWN OUTSIDE OF CELLS ARE TO BE LINE VOLTAGE 3 POSITION SWITCHES FOR CELL LIGHTS. ALL OTHER SWITCHES AND SENSORS ARE TO BE LOW VOLTAGE.
- LIGHTING, CONDUIT, EQUIPMENT, ETC. IS NOT TO BE INSTALLED BELOW FAN COIL UNITS. MAINTENANCE ACCESS TO FAN COIL UNITS IS TO BE MAINTAINED. CONTRACTOR TO COORDINATE WITH MECHANICAL TRADE INSTEAD FOR INSTALLED FAN COIL LOCATIONS AND SIZES.

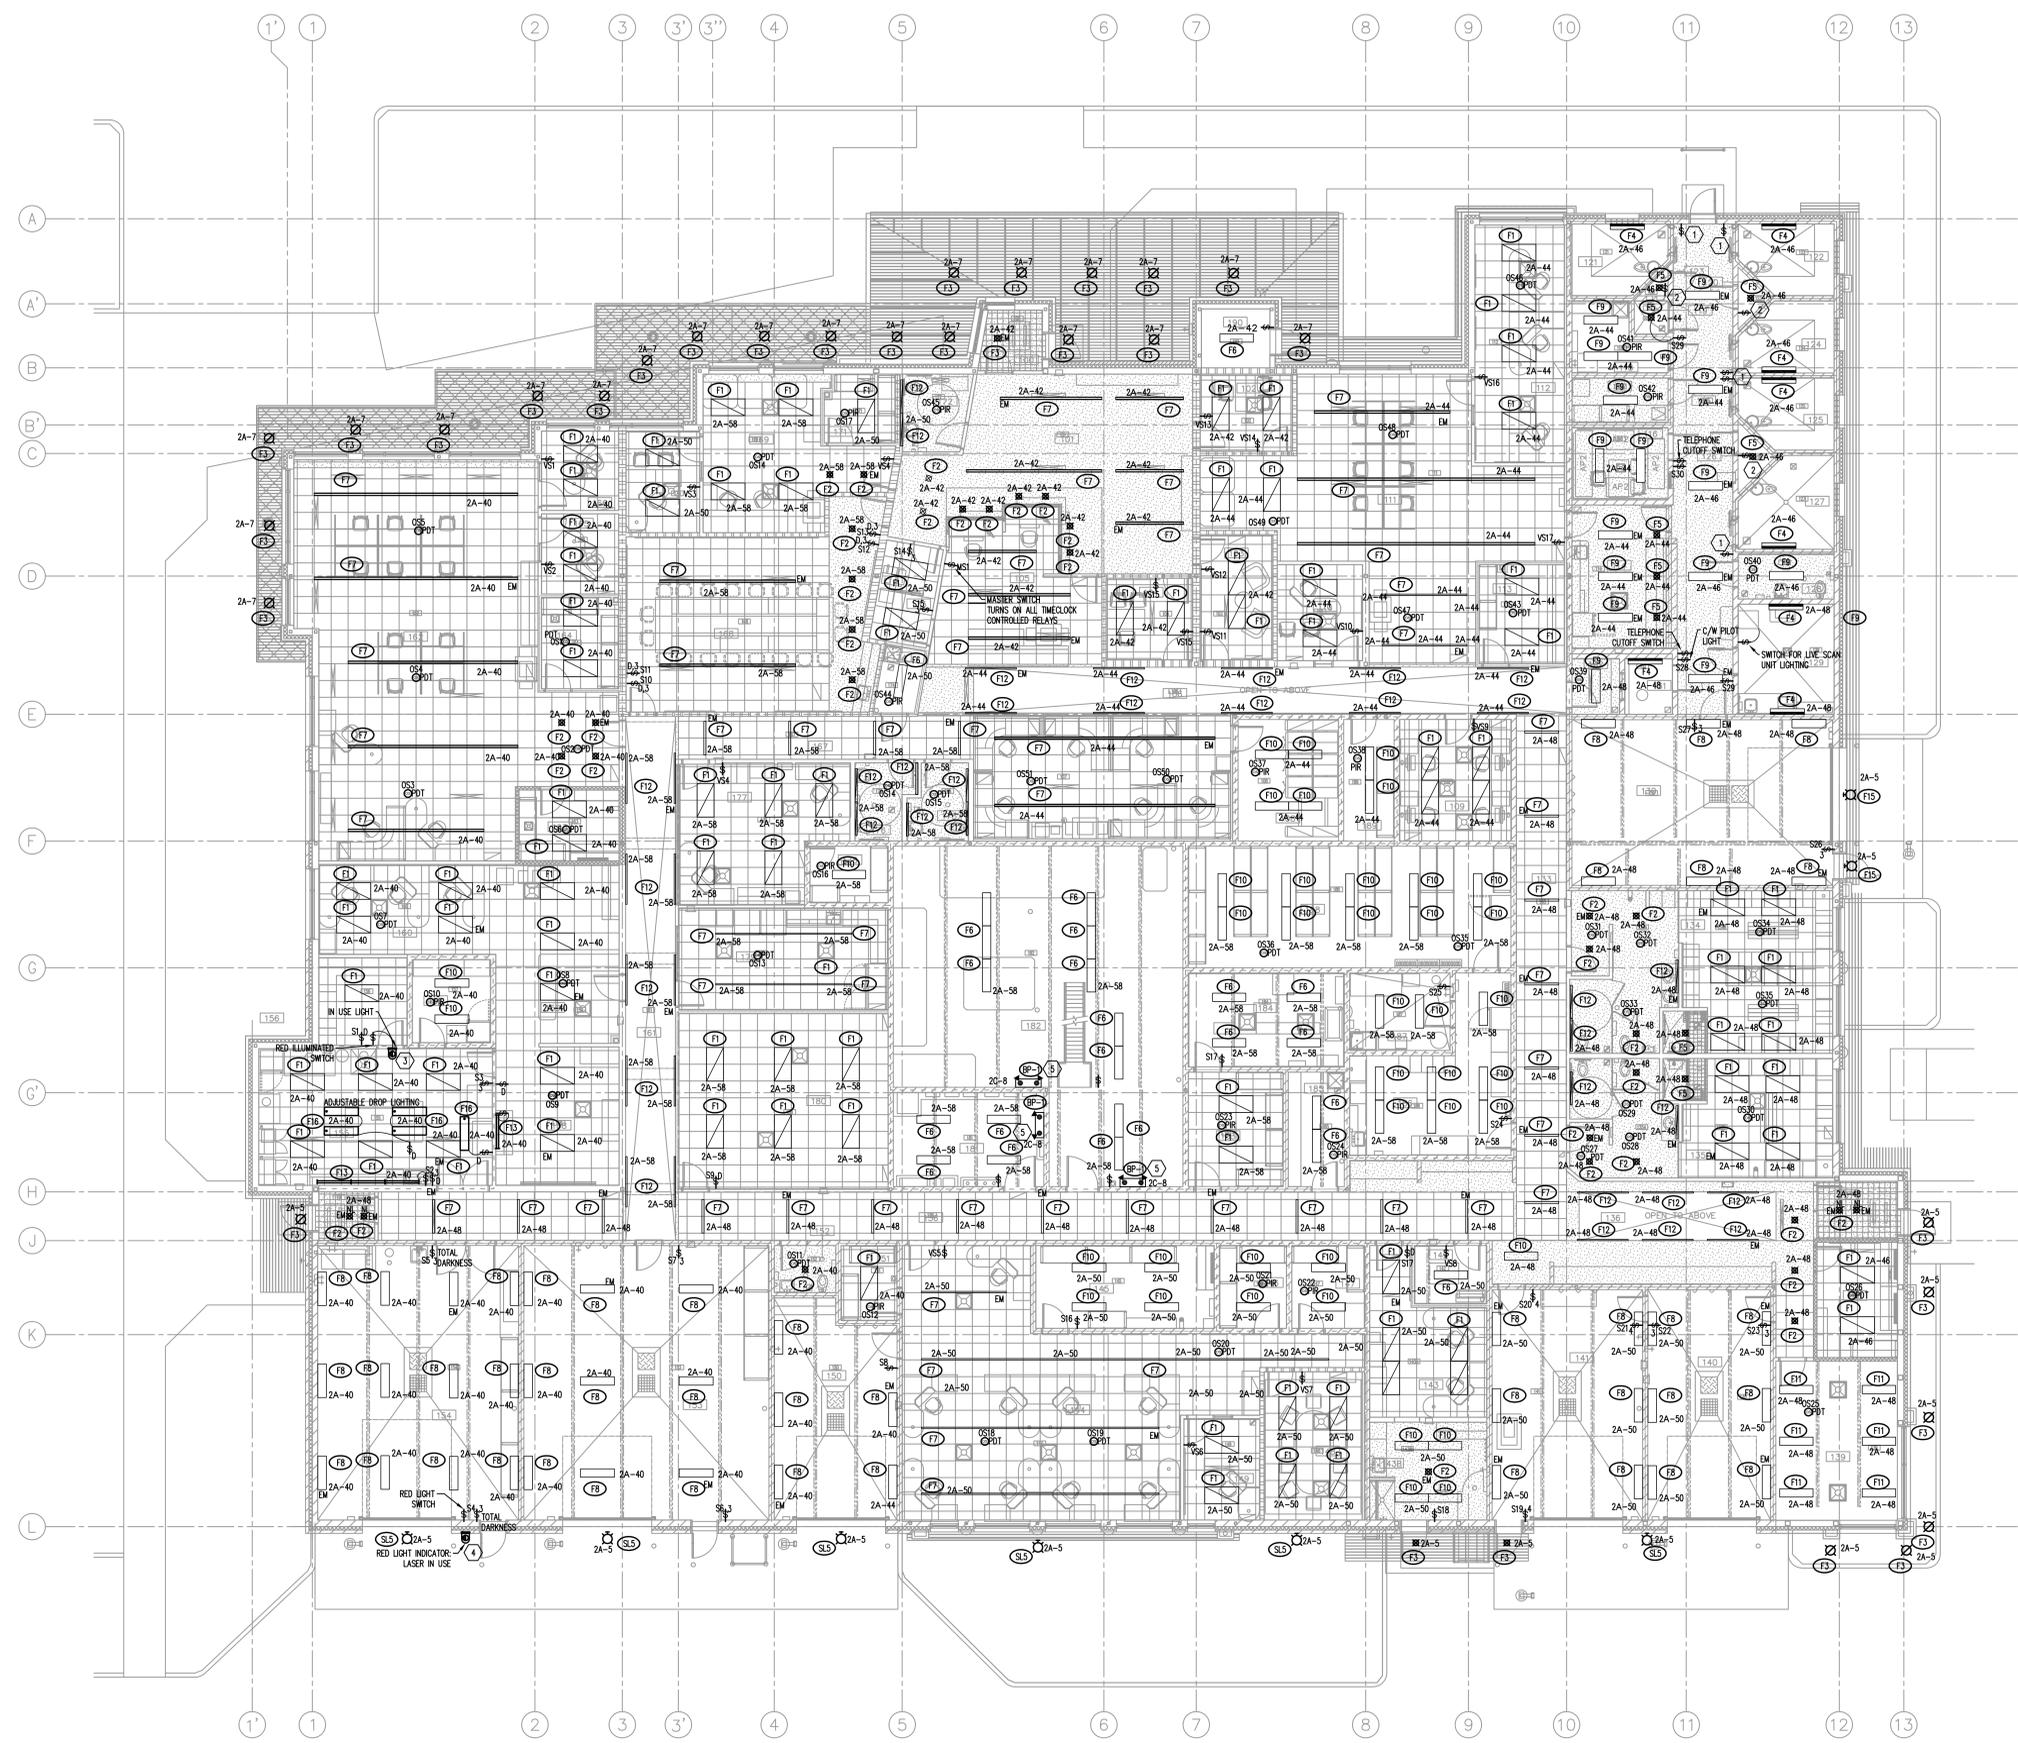

**LIGHTING PLAN**  
E-300 SCALE: 1:100

PERMIT TO PRACTICE  
WILLIAMS ENGINEERING CANADA INC.  
PERMIT NUMBER  
P 10527  
The Association of Prof. Engineers  
and Geoscientists of Alberta.

EDMONTON OFFICE  
Suite 620  
1088-102 Street  
Edmonton, AB T5J 2B1  
Fax: (780) 462-2393  
Tel: (780) 462-1520  
info@williamseng.com  
www.williamseng.com

WILLIAMS  
ENGINEERING  
**WE**

Issues/Revisions

No.	Description	Date	By
A	ISSUED FOR 50% REVIEW	2018.03.16	BR
B	ISSUED FOR 66% REVIEW	2018.05.15	BR
C	ISSUED FOR 75% REVIEW	2018.06.26	BR
D	ISSUED FOR TENDER	2019.01.09	BR



Client: **Government of Canada** / **Gouvernement du Canada**



Project: **COALDALE PROTECTIVE SERVICES BUILDING**

Scale: AS NOTED	Designed By: BR
Project No.: 0000	Drawn By: BR
Date: 2001 JANUARY 00	Checked By: MF

Drawing Title: **LIGHTING PLAN**

Drawing No.

**E3.0**

Notes:

- Do not scale drawing
- It is the responsibility of the appropriate Contractor to check and verify all dimensions on site and report all errors and/or omissions to the Architect or Engineer
- It is the responsibility of the appropriate Contractor to comply with all Codes and Regulations applicable to the performance of their work.
- All Drawings and Specifications are instruments of service and are the property of the Architect or Engineer. This Drawing is the Copyright of STEPHENS KOZAK ACI ARCHITECTS AND PLANNERS or the Consultant named on this Drawing as at the date shown and may not be used or reproduced in whole or in part without the express written consent of the Architect or Engineer.
- All dimensions are in mm unless noted otherwise.



LAMP DESCRIPTION: 3800 LUMEN LED  
LAMP TEMPERATURE: 4100K  
LAMP QUANTITY: N/A  
MOUNTING: RECESSED  
HOUSING: STEEL  
REFLECTOR: N/A  
LENS: N/A  
DRIVER: 120V, DIMMABLE DRIVER

SPECIAL REQUIREMENTS:  
EM TAG = INCLUDE INTEGRAL EMERGENCY BATTERY

ACCEPTABLE PRODUCTS:  
MANUFACTURER PART NUMBER  
#1: METALUMEN TC4-2L4024-MW-W-12-1-T-4  
#2:  
#3: ACCEPTED SUBSTITUTION

Products are listed to establish reference standards.  
For acceptance of substitutions refer to General Conditions of specification.

**WE** LUMINAIRE SCHEDULE TYPE No. F1



LAMP DESCRIPTION: 2000 LUMEN LED  
LAMP TEMPERATURE: 4100K  
LAMP QUANTITY: N/A  
MOUNTING: RECESSED  
HOUSING: STEEL  
REFLECTOR: N/A  
LENS: N/A  
DRIVER: 120V, DIMMABLE DRIVER

SPECIAL REQUIREMENTS:  
EM TAG = INCLUDE REMOTE EMERGENCY BATTERY INSTALLED NEAR FIXTURE

ACCEPTABLE PRODUCTS:  
MANUFACTURER PART NUMBER  
#1: 3G 3G-DL4500-2200-H90-40L-300-120-DIM-WT-M-NC  
#2:  
#3: ACCEPTED SUBSTITUTION

Products are listed to establish reference standards.  
For acceptance of substitutions refer to General Conditions of specification.

**WE** LUMINAIRE SCHEDULE TYPE No. F2



LAMP DESCRIPTION: 850 LUMEN LED  
LAMP TEMPERATURE: 3000K  
LAMP QUANTITY: N/A  
MOUNTING: RECESSED  
HOUSING: SATIN NICKEL  
REFLECTOR: N/A  
LENS: N/A  
DRIVER: 120V, DIMMABLE DRIVER

SPECIAL REQUIREMENTS:  
MOUNT DRIVERS INSIDE CEILING OF INTERIOR; GROUP AS EXTENSION ALLOWS

ACCEPTABLE PRODUCTS:  
MANUFACTURER PART NUMBER  
#1: DAL5 7006-SN-7000-EXT230  
#2:  
#3: ACCEPTED SUBSTITUTION

Products are listed to establish reference standards.  
For acceptance of substitutions refer to General Conditions of specification.

**WE** LUMINAIRE SCHEDULE TYPE No. F3



LAMP DESCRIPTION: 3200 LUMEN LED  
LAMP TEMPERATURE: 4100K  
LAMP QUANTITY: 1  
MOUNTING: SURFACE  
HOUSING: 14 GAUGE STEEL  
REFLECTOR: N/A  
LENS: AS NOTED BELOW  
DRIVER: 120V, DIMMABLE DRIVER

SPECIAL REQUIREMENTS:  
FIXTURE TO BE C/W LED NIGHT LIGHT, PRISMATIC ACRYLIC DIFFUSER (0.25" CLEAR POLYCARBONATE OUTER LENS, 1/4 GAUGE STEEL HOUSING)

ACCEPTABLE PRODUCTS:  
MANUFACTURER PART NUMBER  
#1: COOPER FMC-X-4-LD4-1-STD-120-80/86-EDD1-1-LNL  
#2:  
#3: ACCEPTED SUBSTITUTION

Products are listed to establish reference standards.  
For acceptance of substitutions refer to General Conditions of specification.

**WE** LUMINAIRE SCHEDULE TYPE No. F4



LAMP DESCRIPTION: 2250 LUMEN LED  
LAMP TEMPERATURE: 4000K  
LAMP QUANTITY: N/A  
MOUNTING: SURFACE  
HOUSING: STEEL  
REFLECTOR: N/A  
LENS: PEARLESCENT POLYCARBONATE  
DRIVER: 120V, DRIVER

SPECIAL REQUIREMENTS:  
COLOR BY ARCHITECT, SHOWER RATED

ACCEPTABLE PRODUCTS:  
MANUFACTURER PART NUMBER  
#1: KENALL MRF-EP-182-20L40K-120  
#2: RAB LIGHTING VAN 11  
#3: ACCEPTED SUBSTITUTION

Products are listed to establish reference standards.  
For acceptance of substitutions refer to General Conditions of specification.

**WE** LUMINAIRE SCHEDULE TYPE No. F5



LAMP DESCRIPTION: 5000 LUMEN LED  
LAMP TEMPERATURE: 4000K  
LAMP QUANTITY: LED  
MOUNTING: SURFACE/PENDANT MOUNT  
HOUSING: STEEL  
REFLECTOR: N/A  
LENS: FROSTED LENS  
DRIVER: 120V, DIMMABLE DRIVER

SPECIAL REQUIREMENTS:

ACCEPTABLE PRODUCTS:  
MANUFACTURER PART NUMBER  
#1: COLUMBIA LCL-4-40-ML-E-U  
#2:  
#3: ACCEPTED SUBSTITUTION

Products are listed to establish reference standards.  
For acceptance of substitutions refer to General Conditions of specification.

**WE** LUMINAIRE SCHEDULE TYPE No. F6



LAMP DESCRIPTION: 1136 LUMEN/FT LED UP/DOWN  
LAMP TEMPERATURE: 4000K  
LAMP QUANTITY: 2  
MOUNTING: SURFACE MOUNT  
HOUSING: STEEL  
REFLECTOR: N/A  
LENS: N/A  
DRIVER: 120V, DIMMABLE DRIVER

SPECIAL REQUIREMENTS:  
RUN LENGTH AS PER DRAWING  
EM TAG = EMERGENCY BATTERY BACKUP 4' SECTION

ACCEPTABLE PRODUCTS:  
MANUFACTURER PART NUMBER  
#1: 3G 3G-2SLI-DI-L2-L2-40K-120-DIM-DD1-WH-60-1C  
#2:  
#3: ACCEPTED SUBSTITUTION

Products are listed to establish reference standards.  
For acceptance of substitutions refer to General Conditions of specification.

**WE** LUMINAIRE SCHEDULE TYPE No. F7



LAMP DESCRIPTION: 7700 LUMEN LED  
LAMP TEMPERATURE: 4000K  
LAMP QUANTITY: N/A  
MOUNTING: SURFACE/PENDANT MOUNT  
HOUSING: POLYCARBONATE  
REFLECTOR: N/A  
LENS: GASKETED  
DRIVER: 120V DIMMABLE DRIVER

SPECIAL REQUIREMENTS:  
WET LOCATION RATED  
EM TAG = INCLUDE BUILT IN EMERGENCY BATTERY BACKUP DL

ACCEPTABLE PRODUCTS:  
MANUFACTURER PART NUMBER  
#1: STANPRO VT4-L-54A-A-40X-DIM1  
#2:  
#3: ACCEPTED SUBSTITUTION

Products are listed to establish reference standards.  
For acceptance of substitutions refer to General Conditions of specification.

**WE** LUMINAIRE SCHEDULE TYPE No. F8



LAMP DESCRIPTION: 5900 LUMEN LED  
LAMP TEMPERATURE: 4000K  
LAMP QUANTITY: 1  
MOUNTING: SURFACE MOUNT  
HOUSING: 12 GA STEEL  
REFLECTOR: N/A  
LENS: PRISMATIC ACRYLIC  
DRIVER: 120V ELECTRONIC DRIVER

SPECIAL REQUIREMENTS:  
CONFINEMENT SECURE FIXTURE  
EM TAG = ELLOW 10W INTEGRAL EMERGENCY BATTERY PACK

ACCEPTABLE PRODUCTS:  
MANUFACTURER PART NUMBER  
#1: COOPER FCT-X-4-LD4-2-STD-50-120-80/86  
#2: KENALL SDA-4-3/3-67L40K-DCC-120-1/9-1  
#3: ACCEPTED SUBSTITUTION

Products are listed to establish reference standards.  
For acceptance of substitutions refer to General Conditions of specification.

**WE** LUMINAIRE SCHEDULE TYPE No. F9



LAMP DESCRIPTION: 2869 LUMENS LED  
LAMP TEMPERATURE: 4000K  
LAMP QUANTITY: N/A  
MOUNTING: SURFACE MOUNT  
HOUSING: ALUMINUM  
REFLECTOR: N/A  
LENS: FLUSH LENS  
DRIVER: 120V DIMMABLE DRIVER

SPECIAL REQUIREMENTS:

ACCEPTABLE PRODUCTS:  
MANUFACTURER PART NUMBER  
#1: METALUMEN RM4D-1L40K-4-M-W-L3-1-5-1-90  
#2:  
#3: ACCEPTED SUBSTITUTION

Products are listed to establish reference standards.  
For acceptance of substitutions refer to General Conditions of specification.

**WE** LUMINAIRE SCHEDULE TYPE No. F10



LAMP DESCRIPTION: 2869 LUMENS LED  
LAMP TEMPERATURE: 4000K  
LAMP QUANTITY: N/A  
MOUNTING: SURFACE MOUNT  
HOUSING: ALUMINUM  
REFLECTOR: N/A  
LENS: FLUSH LENS  
DRIVER: 120V DIMMABLE DRIVER

SPECIAL REQUIREMENTS:

ACCEPTABLE PRODUCTS:  
MANUFACTURER PART NUMBER  
#1: METALUMEN RM4D-1L40K-4-M-W-L3-1-5-1-90  
#2:  
#3: ACCEPTED SUBSTITUTION

Products are listed to establish reference standards.  
For acceptance of substitutions refer to General Conditions of specification.

**WE** LUMINAIRE SCHEDULE TYPE No. F11



LAMP DESCRIPTION: LED 535 LUMENS  
LAMP TEMPERATURE: 4000K  
LAMP QUANTITY: 1  
MOUNTING: WALL MOUNT  
HOUSING: ALUMINUM  
REFLECTOR: N/A  
LENS: ACRYLIC  
DRIVER: 120V DIMMABLE DRIVER

SPECIAL REQUIREMENTS:  
EM TAG = EMERGENCY BATTERY BACKUP 4' SECTION

ACCEPTABLE PRODUCTS:  
MANUFACTURER PART NUMBER  
#1: 3G 2G-DML-D-12-40K-120-DIM-DD1-WH  
#2:  
#3: ACCEPTED SUBSTITUTION

Products are listed to establish reference standards.  
For acceptance of substitutions refer to General Conditions of specification.

**WE** LUMINAIRE SCHEDULE TYPE No. F12



LAMP DESCRIPTION: 10W/LED  
LAMP TEMPERATURE: 4000K  
LAMP QUANTITY: N/A  
MOUNTING: UNDER COUNTER, SEE ARCH ELEV.  
HOUSING: ALUMINUM  
REFLECTOR: N/A  
LENS: FROSTED LENS  
DRIVER: 120V, DIMMABLE DRIVER

SPECIAL REQUIREMENTS:  
720mm LENGTH

ACCEPTABLE PRODUCTS:  
MANUFACTURER PART NUMBER  
#1: NATECH NTLB-14-FR-FC-UT60-NW-24VDC  
#2:  
#3: OR APPROVED EQUAL

Products are listed to establish reference standards.  
For acceptance of substitutions refer to General Conditions of specification.

**WE** LUMINAIRE SCHEDULE TYPE No. F13



LAMP DESCRIPTION: 231 LUMENS LED  
LAMP TEMPERATURE: 4000K  
LAMP QUANTITY: N/A  
MOUNTING: WALL MOUNT  
HOUSING: ALUMINUM  
REFLECTOR: N/A  
LENS:  
DRIVER: 120V DIMMABLE DRIVER

SPECIAL REQUIREMENTS:

ACCEPTABLE PRODUCTS:  
MANUFACTURER PART NUMBER  
#1: COOPER ENV-F01-LED-E1-BL3-AP-7030  
#2:  
#3: ACCEPTED SUBSTITUTION

Products are listed to establish reference standards.  
For acceptance of substitutions refer to General Conditions of specification.

**WE** LUMINAIRE SCHEDULE TYPE No. F15



LAMP DESCRIPTION: 5000 LUMENS LED  
LAMP TEMPERATURE: 5000K  
LAMP QUANTITY: N/A  
MOUNTING: PENDANT MOUNT  
HOUSING: ALUMINUM  
REFLECTOR: N/A  
LENS:  
DRIVER: 120V DIMMABLE DRIVER

SPECIAL REQUIREMENTS:

ACCEPTABLE PRODUCTS:  
MANUFACTURER PART NUMBER  
#1: COOPER 4WSL-D2-50-SPS-UNV-L850-CD-1  
#2:  
#3: ACCEPTED SUBSTITUTION

Products are listed to establish reference standards.  
For acceptance of substitutions refer to General Conditions of specification.

**WE** LUMINAIRE SCHEDULE TYPE No. F16

**GENERAL NOTES:**

- FOR SOME OF THE FIXTURES ABOVE THERE IS A NOTE REGARDING THE EM TAG. THESE FIXTURES ARE TO BE SPECIFIED THE SAME AS THE NORMAL FIXTURE EXCEPT THEY ARE TO INCLUDE INTEGRAL BATTERY BACKUP.

EDMONTON OFFICE  
Suite 4020  
10885-102 Street  
Edmonton, AB T5A 3B1  
Box 1700, 04-2033  
Tel/Fax: (403) 242-2393  
Fax: (780) 454-1232  
info@wemengrting.com  
www.wemengrting.com

WILLIAMS  
ENGINEERING  
INC.

**WE**

REG. NO. 2006-01

Issues/Revisions

No.	Description	Date	By
A	ISSUED FOR REVIEW		
B	ISSUED FOR 66% REVIEW	2018.05.15	BR
C	ISSUED FOR 75% REVIEW	2018.06.26	BR
D	ISSUED FOR TENDER	2019.01.09	BR

Seal



Client  
Government of Canada / Gouvernement du Canada



Project  
**COALDALE PROTECTIVE SERVICES BUILDING**

Scale	AS NOTED	Designed By	BR
Project No.	0000	Drawn By	BR
Date	2001 JANUARY 00	Checked By	MF

Drawing Title

**LUMINAIRE SCHEDULE**

Drawing No.

**E3.1**

- Notes:
- Do not scale drawing
  - It is the responsibility of the appropriate Contractor to check and verify all dimensions on site and report all errors and/or omissions to the Architect or Engineer
  - It is the responsibility of the appropriate Contractor to comply with all Codes and Regulations applicable to the performance of their work.
  - All Drawings and Specifications are instruments of service and are the property of the Architect or Engineer. This Drawing is the Copyright of STEPHENS KOZAK ACI ARCHITECTS AND PLANNERS or the Consultant named on this Drawing as at the date shown and may not be used or reproduced in whole or in part without the express written consent of the Architect or Engineer.
  - All dimensions are in mm unless noted otherwise.



ELECTRICAL SYMBOL LEGEND	
	MANUAL PULLSTATION
	HORN/STROBE COMBO
	STORAGE
	HEAT DETECTOR H = HIGH TEMPERATURE L = LOW TEMPERATURE R = RATE OF RISE
	SMOKE DETECTOR CG = SECURE CAGE AROUND DETECTOR
	CEILING MOUNT EXIT SIGN
	WALL MOUNT EXIT SIGN
	SMOKE DAMPER
	DUCT SMOKE DETECTOR

- GENERAL NOTES:**
- SMOKE DETECTOR CAGES IN ROOMS 116, 121, 122, 124, 125, 127, AND 129, TO BE ONE OF THREE TYPES: SIMPLEX GRINNELL GUARD MODEL 2088-9829C, GE SECURITY GUARD MODEL 6255-004 OR NOTIFIER GUARD MODEL SMOKE C1A-2.
  - DUCT DETECTOR TO BE INSTALLED ON SUPPLY SIDE OF ERV-1 SUPPLY FAN DUCT IN STRAIGHT SECTION AS PER CAN/ULC S-524. COORDINATE LOCATION ONSITE.
  - EXIT SIGN TYPE EX-1 TO BE EQUAL TO ANULITE RPST-1-W-WHT-BAT LED EXIT SIGN.
  - EXIT SIGN TYPE EX-2 TO BE EQUAL TO ANULITE RPR-1-W-WHT-BAT VANDAL RESISTANT LED EXIT LIGHT.

- KEYNOTES:**
- SMOKE DETECTORS CONNECTED TO SMOKE DAMPER IN TRANSFER DUCT. SMOKE DAMPER TO CLOSE ON DETECTION OF SMOKE FROM SMOKE DETECTORS. PROVIDE POWER TO SMOKE DAMPER AND RELAY FOR CONNECTION TO SMOKE DETECTORS.
  - DUCT SMOKE DETECTOR CONNECTED TO SMOKE DAMPER IN TRANSFER DUCT. DUCT SMOKE DETECTOR TO BE MOUNTED DOWNSTREAM OF THE SMOKE DAMPER. SMOKE DAMPER TO CLOSE ON DETECTION OF SMOKE FROM SMOKE DETECTOR. PROVIDE POWER TO SMOKE DAMPER AND RELAY FOR CONNECTION TO SMOKE DETECTOR.

PERMIT TO PRACTICE  
WILLIAMS ENGINEERING CANADA INC.  
PERMIT NUMBER  
P 10527  
The Association of Prof. Engineers  
and Geoscientists of Alberta.

EDMONTON OFFICE  
Suite 620  
10885-102 Street  
Edmonton, AB T5A 2B1  
Box 7810-04-2019  
Tel/Fax: 453-262-2393  
Fax: 781-65-1200  
info@wemeng.com  
www.wemeng.com

WILLIAMS  
ENGINEERING  
CANADA INC.  
**WE**

REC 20 # 2086/00

Issues/Revisions

No.	Description	Date	By
A	ISSUED FOR 50% REVIEW		BR
B	ISSUED FOR 66% REVIEW	2018.05.15	BR
C	ISSUED FOR 75% REVIEW	2018.06.26	BR
D	ISSUED FOR TENDER	2019.01.09	BR



Client Government of Canada / Gouvernement du Canada

**Canada**

Project  
**COALDALE PROTECTIVE SERVICES BUILDING**

Scale	AS NOTED	Designed By	BR
Project No.	33866.00	Drawn By	BR
Date	2001 JANUARY 00	Checked By	MF

Drawing Title  
**LIFE SAFETY PLAN**

 

Drawing No.

**E4.0**

**LIFE SAFETY PLAN**  
E-400 SCALE: 1:100

Notes:

- Do not scale drawing
- It is the responsibility of the appropriate Contractor to check and verify all dimensions on site and report all errors and/or omissions to the Architect or Engineer
- It is the responsibility of the appropriate Contractor to comply with all Codes and Regulations applicable to the performance of their work.
- All Drawings and Specifications are instruments of service and are the property of the Architect or Engineer. This Drawing is the Copyright of STEPHENS KOZAK ACI ARCHITECTS AND PLANNERS or the Consultant named on this Drawing as at the date shown and may not be used or reproduced in whole or in part without the express written consent of the Architect or Engineer.
- All dimensions are in mm unless noted otherwise.

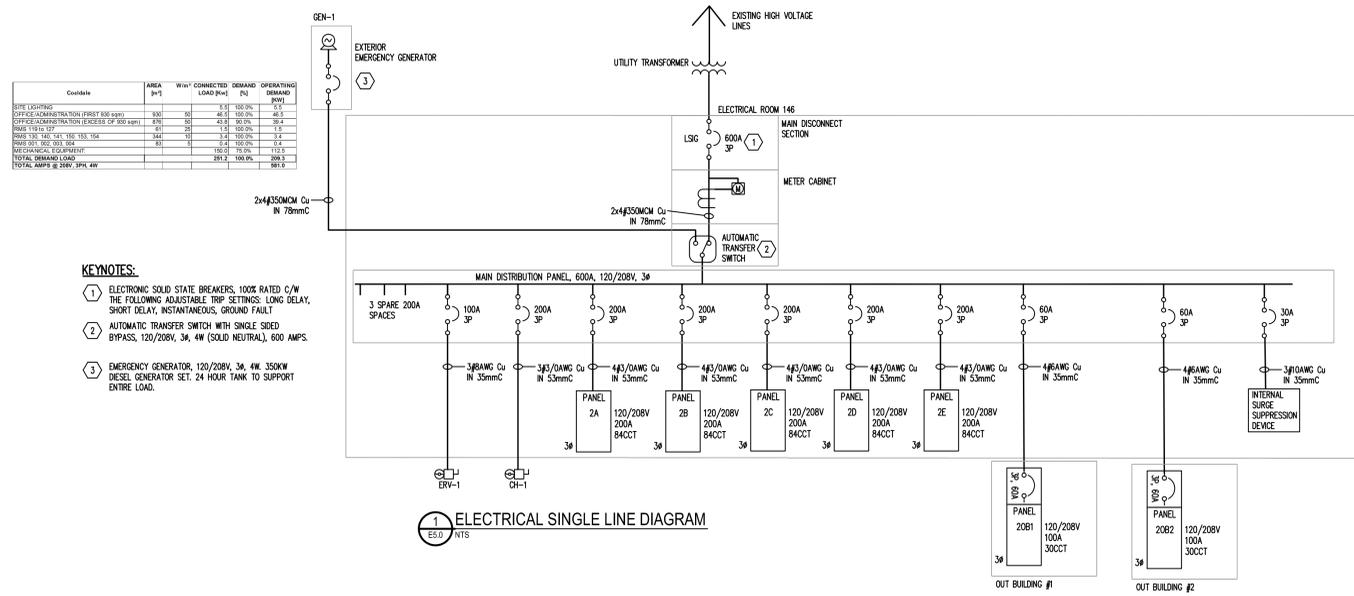

EDMONTON OFFICE  
1080 - 99 Street  
Edmonton AB T5J 1B1  
Tel: (781) 424-2266  
Cell: (403) 424-2266  
Fax: (781) 424-1030  
williams@williamsengineering.com  
www.williamsengineering.com

WILLIAMS  
ENGINEERING  
INC.

No.	Description	Date	By
A	ISSUED FOR 50% REVIEW	2018.03.16	BR
B	ISSUED FOR 66% REVIEW	2018.05.15	BR
C	ISSUED FOR 75% REVIEW	2018.06.26	BR
D	ISSUED FOR TENDER	2019.01.09	BR



Client Government of Canada / Gouvernement du Canada



Project  
**COALDALE PROTECTIVE SERVICES BUILDING**

Scale	AS NOTED	Designed By	BR
Project No.	0000	Drawn By	BR
Date	2001 JANUARY 00	Checked By	MF

Drawing Title  
**SINGLE LINE DIAGRAM**

Drawing No.

E5.0




PANEL 2C		OCTS	LINE VOLTAGE	#	WIRE	MAIN BUS	MAIN BREAKER	ICR	MOUNTING	LOCATION	FEEDER						
		84	120/208V	3	4	225A	200A-3P	10KAC	SURFACE	MECHANICAL ROOM	4#3/0AWG Cu						
NOTES: *UNSWITCHED NIGHT LIGHTING **BREAKER LOCK ON PAINTED RED ***BREAKER LOCK ON																	
LOAD [kVA]			DESCRIPTION	POLE	AMP	CCT #	A	B	C	CCT #	AMP	POLE	DESCRIPTION	LOAD [kVA]			
A	B	C												A	B	C	
0.4			B-1	1	15	1				2	25	1	FC-13	1.2			
	0.4		B-2	1	15	3				4	25	1	FC-14		1.2		
		0.4	HU-1	1	15	5				6	25	1	FC-15			1.2	
0.4						7				8	15	1	EMERGENCY LIGHTING BATTERY PACKS	0.2			
	0.4		P-3	2	20					9			SPARE				
						11				12	20	1	SPARE				
0.4			P-4	2	20					13			EF-1	0.8			
	0.4					15				16	15	1	EF-2		1.0		
		0.2	P-5	3	30					17			EF-4			0.8	
0.4						19				20	15	1	EF-5	0.8			
	0.4					21				22	15	1	F-1			0.4	
		0.2	P-6	3	30					23			SMOKE DAMPERS	1.0			
0.4						25				26						0.4	
	0.4		P-7	1	15	27				28	15	3	EF-14			0.4	
		0.8	DWH-2	1	15	29				30				0.4			
0.4			EF-6	1	15	31				32				1.5			
	0.4		EF-7	1	15	33				34	25	3	CU-1		1.5		
		0.4	OU-1	1	15	35				36						1.5	
0.4			SP-1	1	15	37				38	15	1	SPARE				
	0.3		UH-1, FF-3	1	15	39				40	15	1	BMS CONTROLLER		0.4		
		0.3	UH-2, UH-3	1	15	41				42	15	1	BMS CONTROLLER		0.4		
0.4			DWH-1	1	15	43				44	15	1	ROOF RECEPTACLE	0.8			
	0.3		TK-5,6	1	15	45				46	15	1	ROOF RECEPTACLE	0.8			
		0.4	EF-3	1	15	47				48	15	1	SPARE				
0.4			EF-10,11	1	15	49				50							
		0.4	EF-12,13	1	15	51				52	15	2	RWL HEAT TRACE				
		0.3	UH-4, UH-5	1	15	53				54							
0.3			UH-6, FF-2	1	15	55				56							
	0.3		FF-1	1	15	57				58							
		0.3	TP-1	1	15	59				60							
1.2			FC-1	1	25	61				62	30	1	LS-30R RECEPTACLE				
	1.2		FC-2	1	25	63				64							
		1.2	FC-3	1	25	65				66	15	1	SPARE				
1.2			FC-4	1	25	67				68	15	1	SPARE				
	1.2		FC-5	1	25	69				70	15	1	SPARE				
		1.2	FC-6	1	25	71				72							
1.2			FC-7	1	25	73				74							
		1.2	FC-8	1	25	75				76							
	1.2		FC-9	1	25	77				78							
1.2			FC-10	1	25	79				80							
		1.2	FC-11	1	25	81				82							
		1.2	FC-12	1	25	83				84							
8.3	8.5	8.1	PHASE A	13.8	kVA	115.0	A							5.5	5.7	4.3	
			PHASE B	14.2	kVA	118.3	A										
			PHASE C	12.4	kVA	103.3	A										
			TOTAL	40.4	kVA	112.2	A										

PANEL 20B1		OCTS	LINE VOLTAGE	#	WIRE	MAIN BUS	MAIN BREAKER	ICR	MOUNTING	LOCATION	FEEDER					
		42	120/208V	3	4	225A	100A-3P	10KAC	SURFACE	OUTBUILDING	4#3AWG Cu					
NOTES: *UNSWITCHED NIGHT LIGHTING **BREAKER LOCK ON PAINTED RED ***BREAKER LOCK ON																
LOAD [kVA]			DESCRIPTION	POLE	AMP	CCT #	A	B	C	CCT #	AMP	POLE	DESCRIPTION	LOAD [kVA]		
A	B	C												A	B	C
0.8			LIGHTING	1	15	1				2				0	0	0
	0.7		DUPLEX RECEPTACLE	1	15	3				4						
		0.5	DUPLEX RECEPTACLE	1	15	5				6						
1.0			OVERHEAD DOOR OPERATOR POWER	1	15	7				8						
	1.0		OVERHEAD DOOR OPERATOR POWER	1	15	9				10						
		0.3	EXTERIOR LIGHTING	1	15	11				12						
0.1			EXIT LIGHTING	1	15	13				14						
						15				16						
						17				18						
						19				20						
						21				22						
						23				24						
						25				26						
						27				28						
						29				30						
1.1	1.7	0.8	PHASE A	1.1	kVA	9.2	A							0.0	0.0	0.0
			PHASE B	1.7	kVA	14.2	A									
			PHASE C	0.8	kVA	6.7	A									
			TOTAL	3.6	kVA	10.0	A									

PANEL 20B2		OCTS	LINE VOLTAGE	#	WIRE	MAIN BUS	MAIN BREAKER	ICR	MOUNTING	LOCATION	FEEDER					
		42	120/208V	3	4	225A	100A-3P	10KAC	SURFACE	OUTBUILDING	4#3AWG Cu					
NOTES: *UNSWITCHED NIGHT LIGHTING **BREAKER LOCK ON PAINTED RED ***BREAKER LOCK ON																
LOAD [kVA]			DESCRIPTION	POLE	AMP	CCT #	A	B	C	CCT #	AMP	POLE	DESCRIPTION	LOAD [kVA]		
A	B	C												A	B	C
0.8			LIGHTING	1	15	1				2				0	0	0
	0.7		DUPLEX RECEPTACLE	1	15	3				4						
		0.5	DUPLEX RECEPTACLE	1	15	5				6						
1.0			OVERHEAD DOOR OPERATOR POWER	1	15	7				8						
	1.0		OVERHEAD DOOR OPERATOR POWER	1	15	9				10						
		0.3	EXTERIOR LIGHTING	1	15	11				12						
0.1			EXIT LIGHTING	1	15	13				14						
		1.0	OVERHEAD DOOR OPERATOR POWER	1	15	15				16						
						17				18						
						19				20						
						21				22						
						23				24						
						25				26						
						27				28						
						29				30						
1.1	2.7	0.8	PHASE A	1.1	kVA	9.2	A							0.0	0.0	0.0
			PHASE B	2.7	kVA	22.5	A									
			PHASE C	0.8	kVA	6.7	A									
			TOTAL	4.6	kVA	12.8	A									

 Notes:  
 - Do not scale drawing  
 - It is the responsibility of the appropriate Contractor to check and verify all dimensions on site and report all errors and/or omissions to the Architect or Engineer  
 - It is the responsibility of the appropriate Contractor to comply with all Codes and Regulations applicable to the performance of their work.  
 - All Drawings and Specifications are instruments of service and are the property of the Architect or Engineer. This Drawing is the Copyright of STEPHENS KOZAK ACI ARCHITECTS AND PLANNERS or the Consultant named on this Drawing as at the date shown and may not be used or reproduced in whole or in part without the express written consent of the Architect or Engineer.  
 - All dimensions are in mm unless noted otherwise.



EDMONTON OFFICE  
 1380-10 Street  
 Edmonton AB T5J 1B1  
 Tel: (781) 424-2266  
 Toll-Free: 1-800-323-2266  
 Fax: (781) 424-1033  
 info@williamsengineering.com  
 www.williamsengineering.com

WILLIAMS  
 ENGINEERING  
 WE  
 The Association of Professional Engineers and Geoscientists of Alberta

No.	Description	Date	By
A	ISSUED FOR 50% REVIEW	2018.03.16	BR
B	ISSUED FOR 66% REVIEW	2018.05.15	BR
C	ISSUED FOR 75% REVIEW	2018.06.26	BR
D	ISSUED FOR TENDER	2019.01.09	BR



Client  
 Government of Canada / Gouvernement du Canada

Canada

Project  
 COALDALE PROTECTIVE SERVICES BUILDING

Scale	AS NOTED	Designed By	BR
Project No.	0000	Drawn By	BR
Date	2001 JANUARY 00	Checked By	MF

Drawing Title  
 PANEL 2C, 20B1 & 20B2 SCHEDULES

Drawing No.

E6.1

PANEL 2D		CCTS	LINE VOLTAGE	Ø	WIRE	MAIN BUS	MAIN BREAKER	ICR	MOUNTING	LOCATION	FEEDER						
		B4	120/208V	3	4	225A	200A-3P	14KAC	SURFACE	MECHANICAL ROOM	4#3/0AWG Cu						
NOTES: *UNSWITCHED NIGHT LIGHTING **BREAKER LOCK ON PAINTED RED ***BREAKER LOCK ON																	
LOAD [kVA]			DESCRIPTION	POLE	AMP	CCT #	A	B	C	CCT #	AMP	POLE	DESCRIPTION	LOAD [kVA]			
A	B	C												A	B	C	
0.5			FAUCETS & VALVES, RM 172,175,176	1	15	1				2	25	1	FC-16	1.2			
0.5			FAUCETS & VALVES, RM 128,134,135	1	15	3				4	25	1	FC-17	1.2			
	0.4		EF-8	1	15	5				6	25	1	FC-18			1.2	
	0.4		EF-9	1	15	7				8	25	1	FC-19	1.2			
	0.1		**EXIT SIGNS	1	15	9				10	25	1	FC-20		1.2		
	0.1		**EXIT SIGNS	1	15	11				12	25	1	FC-21			1.2	
0.4			EF-13	1	15	13				14	25	1	FC-22	1.2			
	0			1	15	15				16	25	1	FC-23			1.2	
	0			1	15	17				18	25	1	FC-24			1.2	
	0			1	15	19				20	25	1	FC-25	1.2			
	0			1	15	21				22	25	1	FC-26			1.2	
	0			1	15	23				24	25	1	FC-27			1.2	
	0			1	15	25				26	25	1	FC-28	1.2			
	0			1	15	27				28	25	1	FC-29			1.2	
	1.0		RECEPTACLES, RM 114, MICROWAVE	1	15	29				30	25	1	FC-30			1.2	
1.0			RECEPTACLES, RM 114, FRIDGE	1	15	31				32	25	1	FC-31	1.2			
	1.0		RECEPTACLES, RM 106,111	1	15	33				34	25	1	FC-32			1.2	
	1.0		RECEPTACLES, EXTERIOR WP	1	15	35				36	25	1	FC-33			1.2	
1.0			RECEPTACLES, RM 129	1	15	37				38	25	1	FC-34	1.2			
	1.0		RECEPTACLES, RM 132,130	1	15	39				40						1.2	
	1.0		RECEPTACLES, RM 129, LIVE SCAN UNIT	1	15	41				42						1.2	
1.0			RECEPTACLES, RM 129, LIVE SCAN PRINTER	1	15	43				44						1.2	
	1.0		RECEPTACLES, RM 114	1	15	45				46						1.2	
	1.0		RECEPTACLES, RM 114	1	15	47				48						1.2	
1.0			RECEPTACLES, RM 114	1	15	49				50						1.2	
	1.0		RECEPTACLES, RM 114	1	15	51				52						1.2	
	1.0		RECEPTACLES, RM 120,123,126,115	1	15	53				54						1.2	
1.0			RECEPTACLES, RM 118, WASHER / DRYER	2	30	55				56						1.2	
	1.0					57				58						1.2	
	1.0		RECEPTACLES, RM 118,117	1	15	59				60						1.2	
1.0			RECEPTACLES, RM 112	1	15	61				62						1.2	
	1.0		RECEPTACLES, RM 112	1	15	63				64						1.2	
	1.0		RECEPTACLES, RM 112	1	15	65				66						1.2	
1.0			RECEPTACLES, RM 111	1	15	67				68						1.2	
	1.0		RECEPTACLES, RM 110	1	15	69				70						1.2	
	1.0		RECEPTACLES, RM 111, PRINTER	1	20	71				72						1.2	
1.0			RECEPTACLES, RM 111	1	15	73				74						1.2	
	1.0		RECEPTACLES, RM 111	1	15	75				76						1.2	
	1.0		RECEPTACLES, RM 111,102	1	15	77				78						1.2	
1.0			RECEPTACLES, RM 111	1	15	79				80						1.2	
	1.0		RECEPTACLES, RM 113	1	15	81				82						1.2	
	1.0		RECEPTACLES, RM 103	1	15	83				84						1.2	
9.8	9.6	10.5	PHASE A		17.0	kVA	141.7	A						7.2	7.2	7.2	
			PHASE B		16.8	kVA	140.0	A									
			PHASE C		17.7	kVA	147.5	A									
			TOTAL		51.5	kVA	143.1	A									

PANEL 2E		CCTS	LINE VOLTAGE	Ø	WIRE	MAIN BUS	MAIN BREAKER	ICR	MOUNTING	LOCATION	FEEDER					
		B4	120/208V	3	4	225A	200A-3P	14KAC	SURFACE	MECHANICAL ROOM	4#3/0AWG Cu					
NOTES: *UNSWITCHED NIGHT LIGHTING **BREAKER LOCK ON PAINTED RED ***BREAKER LOCK ON																
LOAD [kVA]			DESCRIPTION	POLE	AMP	CCT #	A	B	C	CCT #	AMP	POLE	DESCRIPTION	LOAD [kVA]		
A	B	C												A	B	C
1.0			RECEPTACLES, RM 155	1	15	1				2		2	RECEPTACLES, RM 155	1.0		
	1.0		RECEPTACLES, RM 155	1	15	3				4						1.0
	1.0		RECEPTACLES, RM 155, DISHWASHER	1	15	5				6		2	RECEPTACLES, RM 155			1.0
	1.0		WASHER, RM 154	1	15	7				8						1.0
	1.0		RECEPTACLES, RM 154	1	15	9				10		2	RECEPTACLES, RM 155			1.0
	1.0		RECEPTACLES, RM 154	1	15	11				12						1.0
1.0			RECEPTACLES, RM 153	1	15	13				14		2	DRIVER, RM154	1.0		
	1.0		RECEPTACLES, RM 153,150	1	15	15				16						1.0
	1.0		RECEPTACLES, RM 150,152	1	15	17				18	15	1	RECEPTACLES, RM 155			1.0
1.0			RECEPTACLES, RM 155	1	15	19				20	15	1	RECEPTACLES, RM 155	1.0		
	1.0		RECEPTACLES, RM 151,145,146,147,143	1	15	21				22	15	1	RECEPTACLES, RM 154			1.0
	1.0		RECEPTACLES, RM 144	1	15	23				24	20	1	CHOPSAW POWER			1.4
	1.0		RECEPTACLES, RM 144	1	15	25				26	15	1	RECEPTACLES, RM 186	1.0		
	1.0		RECEPTACLES, RM 144	1	15	27				28	15	1	RECEPTACLES, RM 101,TV			1.0
	1.0		RECEPTACLES, RM 144	1	15	29				30	15	1	RECEPTACLES, RM 179,VENDING MACHINE			1.0
1.0			RECEPTACLES, RM 144	1	15	31				32	15	1	RECEPTACLES, RM 179,VENDING MACHINE	1.0		
	1.0		RECEPTACLES, RM 145,147	1	15	33				34	15	1	RECEPTACLES, RM 179,FRIDGE			1.0
	1.0		RECEPTACLES, RM 142	1	15	35				36	15	1	RECEPTACLES, RM 168, FRIDGE			1.0
1.0			RECEPTACLES, RM 142	1	15	37				38	15	1	RECEPTACLES, RM 104	1.0		
	1.0		RECEPTACLES, RM 142	1	15	39				40	15	1	RECEPTACLES, RM 105			1.0
	1.0		RECEPTACLES, RM 143	1	15	41				42	15	1	RECEPTACLES, RM 105			1.0
1.0			RECEPTACLES, RM 143	1	15	43				44	15	1	RECEPTACLES, RM 101,105	1.0		
	1.0		RECEPTACLES, RM 140	1	15	45				46	15	1	RECEPTACLES, RM 169,101,100,105			1.0
	1.0		RECEPTACLES, RM 138	1	15	47				48	15	1	RECEPTACLES, RM 169, PRINTER			1.0
1.0			RECEPTACLES, RM 138	1	15	49				50	15	1	RECEPTACLES, RM 169	1.0		
	1.0		RECEPTACLES, RM 133,136	1	15	51				52	15	1	RECEPTACLES, RM 168,170			1.0
	1.0		RECEPTACLES, RM 135	1	15	53				54	15	1	RECEPTACLES, RM 173,174			1.0
1.0			RECEPTACLES, RM 186	1	15	55				56	15	1	RECEPTACLES, RM 168	1.0		
	1.0		RECEPTACLES, RM 186 FRIDGE	1	15	57				58	15	1	RECEPTACLES, RM 168			1.0
	1.0		RECEPTACLES, RM 187	1	15	59				60	15	1	RECEPTACLES, RM 168			1.0
1.0			RECEPTACLES, RM 188,182	1	15	61				62	15	1	RECEPTACLES, RM 175,176	1.0		
	1.0		RECEPTACLES, RM 109	1	15	63				64	15	1	RECEPTACLES, RM 177			1.0
	1.0		RECEPTACLES, RM 109	1	15	65				66	15	1	RECEPTACLES, RM 177			1.0
1.0			RECEPTACLES, RM 109	1	15	67				68	15	1	RECEPTACLES, RM 177	1.0		
	1.0		RECEPTACLES, RM 109	1	15	69				70	15	1	RECEPTACLES, RM 179,TV			1.0
	1.0		RECEPTACLES, RM 180,177,178	1	15	71				72	15	1	RECEPTACLES, RM 179			1.0
1.0			RECEPTACLES, RM 180	1	15	73				74	15	1	RECEPTACLES, RM 179,DISHWASHER	1.0		
	1.0		RECEPTACLES, RM 180	1	15	75				76	15	1	RECEPTACLES, RM 179,MICROWAVE			1.0
	1.0		RECEPTACLES, RM 180	1	15	77				78	15	1	RECEPTACLES, RM 179,MICROWAVE			1.0
1.0			RECEPTACLES, RM 180	1	15	79				80	15	1	RECEPTACLES, RM 179,FRIDGE	1.0		
	1.0		RECEPTACLES, RM 180	1	1											




MECHANICAL EQUIPMENT SCHEDULE									
EQUIP. TAG	DESCRIPTION	LOCATION	KW (HP)/FLA	VOLT/PH.	CONDUIT/WIRE	BREAKER	CCT#	STARTER	REMARKS
								TYPE	
B-1	BOILER	RM 145	FRAC. HP	120V/1φ	21mmC-2#12	15A-1P	2C-1	PACK. UNIT	
B-2	BOILER	RM 145	FRAC. HP	120V/1φ	21mmC-2#12	15A-1P	2C-3	PACK. UNIT	
CH-1/MF C-1	CHILLER	ROOF	167MCA	208V/3φ	53mmC-3#5/0	200A-3P	MOP	PACK. UNIT	
P-1	CIRCULATOR PUMP	RM 145	70W	120V/1φ	21mmC-2#12	15A-1P	2C-1	MAN.	POWERED FROM B-1. ELECTRICIAN TO WIRE.
P-2	CIRCULATOR PUMP	RM 145	70W	120V/1φ	21mmC-2#12	15A-1P	2C-3	MAN.	POWERED FROM B-2. ELECTRICIAN TO WIRE.
P-3	CIRCULATOR PUMP	RM 145	1 HP	208V/1φ	21mmC-2#12	20A-2P	2C-7,9	VFD	
P-4	CIRCULATOR PUMP	RM 145	1 HP	208V/1φ	21mmC-2#12	20A-2P	2C-11,13	VFD	
P-5	VERTICAL INLINE PUMP	RM 145	3 HP	208V/3φ	21mmC-3#10	30A-3P	2C-15,17,19	VFD	
P-6	VERTICAL INLINE PUMP	RM 145	3 HP	208V/3φ	21mmC-3#10	30A-3P	2C-21,23,25	VFD	
P-7	CIRCULATOR PUMP	RM 145	FRAC. HP	120V/1φ	21mmC-2#12	15A-1P	2C-27	MAN.	
SP-1	SUMP PUMP	RM 128/RM 149	1/6HP	120V/1φ	21mmC-2#12	15A-1P	2C-37	MAN.	
UH-1	UNIT HEATER	RM 154	1/6HP	120V/1φ	21mmC-2#12	15A-1P	2C-39	MAN.	
UH-2	UNIT HEATER	RM 153	1/6HP	120V/1φ	21mmC-2#12	15A-1P	2C-41	MAN.	
UH-3	UNIT HEATER	RM 150	1/6HP	120V/1φ	21mmC-2#12	15A-1P	2C-41	MAN.	
UH-4	UNIT HEATER	RM 141	1/6HP	120V/1φ	21mmC-2#12	15A-1P	2C-53	MAN.	
UH-5	UNIT HEATER	RM 140	1/6HP	120V/1φ	21mmC-2#12	15A-1P	2C-53	MAN.	
UH-6	UNIT HEATER	RM 130	1/6HP	120V/1φ	21mmC-2#12	15A-1P	2C-55	MAN.	
UH-7	UNIT HEATER	RM 182	1/6HP	120V/1φ	21mmC-2#12	15A-1P	2C-55	MAN.	
FF-1	FORCE FLOW	RM 101	1/6HP	120V/1φ	21mmC-2#12	15A-1P	2C-41	MAN.	
FF-2	FORCE FLOW	RM 127	1/6HP	120V/1φ	21mmC-2#12	15A-1P	2C-39	MAN.	
FF-3	FORCE FLOW	RM 191	1/6HP	120V/1φ	21mmC-2#12	15A-1P	2C-41	MAN.	
DWH-1	DOMESTIC WATER HEATER	RM 145	6.6FLA	120V/1φ	21mmC-2#12	15A-1P	2C-43	-	
DWH-2	DOMESTIC WATER HEATER	RM 145	6.6FLA	120V/1φ	21mmC-2#12	15A-1P	2C-29	-	
TK-3	FILL TANK	RM 145	1A	120V/1φ	21mmC-2#12	15A-1P	2C-45	-	
TP-1	TRAP PRIMER	TBD	FRAC. HP	120V/1φ	21mmC-2#12	15A-1P	2C-59	-	
TP-2	TRAP PRIMER	TBD	FRAC. HP	120V/1φ	21mmC-2#12	15A-1P	2C-59	-	
TP-3	TRAP PRIMER	TBD	FRAC. HP	120V/1φ	21mmC-2#12	15A-1P	2C-59	-	
ERV-1	SUPPLY FAN LIGHTS	ROOF	40MCA 375W	208V/3φ 120V/1φ	35mmC-3#8 21mmC-2#12	100A-3P 15A-1P	MOP 2C-53	PACK. UNIT	
FC-1	FAN COIL	RM 107	1/2HP	120V/1φ	21mmC-2#12	25A-1P	2C-61	ECM MOTOR, DIRECT DRIVE	
FC-2	FAN COIL	RM 107	1/2HP	120V/1φ	21mmC-2#12	25A-1P	2C-63	ECM MOTOR, DIRECT DRIVE	
FC-3	FAN COIL	RM 105	1/2HP	120V/1φ	21mmC-2#12	25A-1P	2C-65	ECM MOTOR, DIRECT DRIVE	
FC-4	FAN COIL	RM 111	1/2HP	120V/1φ	21mmC-2#12	25A-1P	2C-67	ECM MOTOR, DIRECT DRIVE	
FC-5	FAN COIL	RM 113	1/2HP	120V/1φ	21mmC-2#12	25A-1P	2C-69	ECM MOTOR, DIRECT DRIVE	
FC-6	FAN COIL	RM 111	1/2HP	120V/1φ	21mmC-2#12	25A-1P	2C-71	ECM MOTOR, DIRECT DRIVE	
FC-7	FAN COIL	RM 111	1/2HP	120V/1φ	21mmC-2#12	25A-1P	2C-73	ECM MOTOR, DIRECT DRIVE	
FC-8	FAN COIL	RM 111	1/2HP	120V/1φ	21mmC-2#12	25A-1P	2C-75	ECM MOTOR, DIRECT DRIVE	
FC-9	FAN COIL	RM 111	1/2HP	120V/1φ	21mmC-2#12	25A-1P	2C-77	ECM MOTOR, DIRECT DRIVE	
FC-10	FAN COIL	RM 111	1/2HP	120V/1φ	21mmC-2#12	25A-1P	2C-79	ECM MOTOR, DIRECT DRIVE	
FC-11	FAN COIL	RM 177	1/2HP	120V/1φ	21mmC-2#12	25A-1P	2C-81	ECM MOTOR, DIRECT DRIVE	
FC-12	FAN COIL	RM 179	1/2HP	120V/1φ	21mmC-2#12	25A-1P	2C-83	ECM MOTOR, DIRECT DRIVE	
FC-13	FAN COIL	RM 180	1/2HP	120V/1φ	21mmC-2#12	25A-1P	2C-2	ECM MOTOR, DIRECT DRIVE	
FC-14	FAN COIL	RM 143	1/2HP	120V/1φ	21mmC-2#12	25A-1P	2C-4	ECM MOTOR, DIRECT DRIVE	PROVIDE POWER TO FAN COIL 14W CONDENSATE PUMP FROM FAN COIL.
FC-15	FAN COIL	RM 143	1/2HP	120V/1φ	21mmC-2#12	25A-1P	2C-6	ECM MOTOR, DIRECT DRIVE	
FC-16	FAN COIL	RM 143B	1/2HP	120V/1φ	21mmC-2#12	25A-1P	2D-2	ECM MOTOR, DIRECT DRIVE	
FC-17	FAN COIL	RM 136	1/2HP	120V/1φ	21mmC-2#12	25A-1P	2D-4	ECM MOTOR, DIRECT DRIVE	
FC-18	FAN COIL	RM 139	1/2HP	120V/1φ	21mmC-2#12	25A-1P	2D-6	ECM MOTOR, DIRECT DRIVE	
FC-19	FAN COIL	RM 169	1/2HP	120V/1φ	21mmC-2#12	25A-1P	2D-8	ECM MOTOR, DIRECT DRIVE	
FC-20	FAN COIL	RM 168	1/2HP	120V/1φ	21mmC-2#12	25A-1P	2D-10	ECM MOTOR, DIRECT DRIVE	
FC-21	FAN COIL	RM 169	1/2HP	120V/1φ	21mmC-2#12	25A-1P	2D-12	ECM MOTOR, DIRECT DRIVE	
FC-22	FAN COIL	RM 162	1/2HP	120V/1φ	21mmC-2#12	25A-1P	2D-14	ECM MOTOR, DIRECT DRIVE	
FC-23	FAN COIL	RM 162	1/2HP	120V/1φ	21mmC-2#12	25A-1P	2D-16	ECM MOTOR, DIRECT DRIVE	
FC-24	FAN COIL	RM 162	1/2HP	120V/1φ	21mmC-2#12	25A-1P	2D-18	ECM MOTOR, DIRECT DRIVE	
FC-25	FAN COIL	RM 162	1/2HP	120V/1φ	21mmC-2#12	25A-1P	2D-20	ECM MOTOR, DIRECT DRIVE	
FC-26	FAN COIL	RM 160	1/2HP	120V/1φ	21mmC-2#12	25A-1P	2D-22	ECM MOTOR, DIRECT DRIVE	
FC-27	FAN COIL	RM 159	1/2HP	120V/1φ	21mmC-2#12	25A-1P	2D-24	ECM MOTOR, DIRECT DRIVE	
FC-28	FAN COIL	RM 155	1/2HP	120V/1φ	21mmC-2#12	25A-1P	2D-26	ECM MOTOR, DIRECT DRIVE	

MECHANICAL EQUIPMENT SCHEDULE									
EQUIP. TAG	DESCRIPTION	LOCATION	KW (HP)/FLA	VOLT/PH.	CONDUIT/WIRE	BREAKER	CCT#	STARTER	REMARKS
								TYPE	
FC-29	FAN COIL	RM 183	1/2HP	120V/1φ	21mmC-2#12	25A-1P	2D-28	ECM MOTOR, DIRECT DRIVE	
FC-30	FAN COIL	RM 134	1/2HP	120V/1φ	21mmC-2#12	25A-1P	2D-30	ECM MOTOR, DIRECT DRIVE	
FC-31	FAN COIL	RM 135	1/2HP	120V/1φ	21mmC-2#12	25A-1P	2D-32	ECM MOTOR, DIRECT DRIVE	PROVIDE POWER TO FAN COIL 14W CONDENSATE PUMP FROM FAN COIL.
FC-32	FAN COIL	RM 111	1/2HP	120V/1φ	21mmC-2#12	25A-1P	2D-34	ECM MOTOR, DIRECT DRIVE	
FC-33	FAN COIL	RM 136	1/2HP	120V/1φ	21mmC-2#12	25A-1P	2D-36	ECM MOTOR, DIRECT DRIVE	
FC-34	FAN COIL	RM 159	1/2HP	120V/1φ	21mmC-2#12	25A-1P	2D-38	ECM MOTOR, DIRECT DRIVE	
EF-1	WASHROOM EXHAUST FAN	RM 182	1/6 HP	120V/1φ	21mmC-2#12	15A-1P	2C-14	MAN.	
EF-2	EXHAUST FAN	RM 182	1/6 HP	120V/1φ	21mmC-2#12	15A-1P	2C-16	MAN.	
EF-3	SECURE AREA EXHAUST FAN	RM 182	1/6 HP	120V/1φ	21mmC-2#12	15A-1P	2C-18	MAN.	
EF-4	GARAGE EXHAUST FAN	RM 130	1/6 HP	120V/1φ	21mmC-2#12	15A-1P	2C-18	MAN.	
EF-5	EXHAUST FAN	RM 140	1/6 HP	120V/1φ	21mmC-2#12	15A-1P	2C-20	MAN.	
EF-6	EXHAUST FAN	RM 141	1/6 HP	120V/1φ	21mmC-2#12	15A-1P	2C-31	MAN.	INTERLOCKED WITH LIGHTS VIA EMCS
F-1	RELIEF AIR FAN	RM 139	1/8HP	120V/1φ	21mmC-2#12	15A-1P	2C-22	MAN.	
AQU-1	AIR CONDITIONING UNIT	ROOM 139	2.8 FLA	208V/3φ	21mmC-3#12	15A-3P	2C-32,34,36	PACK. UNIT	POWERED FROM CU-1
CU-1	CONDENSING UNIT	ON ROOF	12.8 FLA	208V/3φ	35mmC-3#10	25A-3P	2C-32,34,36	PACK. UNIT	
HU-1	HUMIDIFIER	ROOM 145	3 FLA	120V/1φ	21mmC-2#12	15A-1P	2C-5	PACK. UNIT	
OI-1	OIL INTERCEPTOR	RM 128/RM 149	5 FLA	120V/1φ	21mmC-2#12	15A-1P	2C-35	PACK. UNIT	
EF-7	EXHAUST FAN	RM 150	1/6 HP	120V/1φ	21mmC-2#12	15A-1P	2C-33	MAN.	
EF-8	EXHAUST FAN	RM 153	1/6 HP	120V/1φ	21mmC-2#12	15A-1P	2D-5	MAN.	
EF-9	EXHAUST FAN	RM 154	1/6 HP	120V/1φ	21mmC-2#12	15A-1P	2D-7	MAN.	
EF-10	CENTRIFUGAL FAN	RM 155	FRAC.	120V/1φ	21mmC-2#12	15A-1P	2C-49	MAN.	LOCAL WALL MOUNTED SWITCH
EF-11	CENTRIFUGAL FAN	RM 155	FRAC.	120V/1φ	21mmC-2#12	15A-1P	2C-49	MAN.	LOCAL WALL MOUNTED SWITCH
EF-12	ROOF EXHAUST	RM 155	FRAC.	120V/1φ	21mmC-2#12	15A-1P	2C-51	MAN.	
EF-13	ROOF EXHAUST	ROOM 143B	FRAC.	120V/1φ	21mmC-2#12	15A-1P	2C-51	MAN.	
EF-14	WET PROCESSING EXHAUST	ROOM 155	3/4 HP	208V/3φ	21mmC-3#12	15A-3P	2C-26,28,30	VFD	C/W VARIABLE SPEED ADJUSTABLE SWITCH

Notes:

 - Do not scale drawing
- It is the responsibility of the appropriate Contractor to check and verify all dimensions on site and report all errors and/or omissions to the Architect or Engineer
- All Drawings and Specifications are instruments of service and are the property of the Architect or Engineer. This Drawing is the Copyright of STEPHENS KOZAK ACI ARCHITECTS AND PLANNERS or the Consultant named on this Drawing as at the date shown and may not be used or reproduced in whole or in part without the express written consent of the Architect or Engineer.
- All dimensions are in mm unless noted otherwise.



EDMONTON OFFICE  
1880 - 99 Street  
Edmonton AB T5J 3B1  
Tel: (780) 424-2266  
Cell: (780) 424-2266  
Fax: (780) 424-1030  
williams@williamsengineering.com  
www.williamsengineering.com

WILLIAMS ENGINEERING  
**WE**

Issues/Revisions

No.	Description	Date	By
A	ISSUED FOR 50% REVIEW	2018.03.16	BR
B	ISSUED FOR 66% REVIEW	2018.05.15	BR
C	ISSUED FOR 75% REVIEW	2018.06.26	BR
D	ISSUED FOR TENDER	2019.01.09	BR



Client

Government of Canada / Gouvernement du Canada

**Canada**

Project  
**COALDALE PROTECTIVE SERVICES BUILDING**


Scale	AS NOTED	Designed By	BR
Project No.	0000	Drawn By	BR
Date	2001 JANUARY 00	Checked By	MF

Drawing Title  
**MECHANICAL EQUIPMENT SCHEDULE**


Drawing No.

E6.4


- Notes:
- Do not scale drawing
  - It is the responsibility of the appropriate Contractor to check and verify all dimensions on site and report all errors and/or omissions to the Architect or Engineer.
  - It is the responsibility of the appropriate Contractor to comply with all Codes and Regulations applicable to the performance of their work.
  - All Drawings and Specifications are instruments of service and are the property of the Architect or Engineer. This Drawing is the Copyright of STEPHENS KOZAK ACI ARCHITECTS AND PLANNERS or the Consultant named on this Drawing as at the date shown and may not be used or reproduced in whole or in part without the express written consent of the Architect or Engineer.
  - All dimensions are in mm unless noted otherwise.

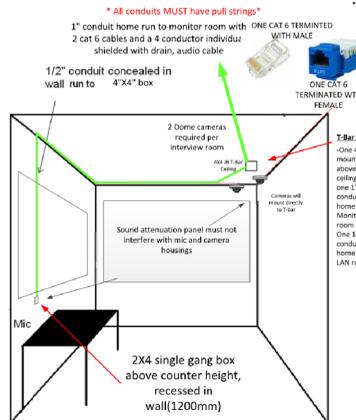


**1 ROOMS #111 & 112 T-BAR CEILING DETAIL**  
SCALE: NTS

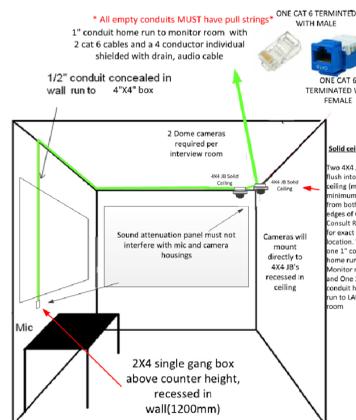


**2 ROOM #119 SOLID CEILING DETAIL**  
SCALE: NTS

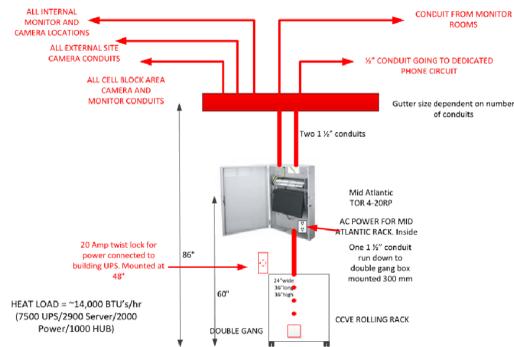


**3 ROOM 139 CCVE TYPICAL FIT UP DETAIL**  
SCALE: NTS

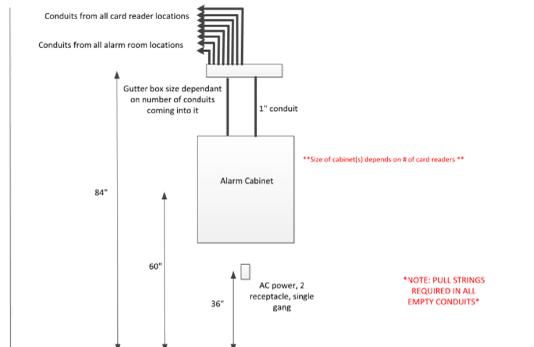


**4 ROOM 139 ALARM PANEL TYPICAL FIT UP DETAIL**  
SCALE: NTS

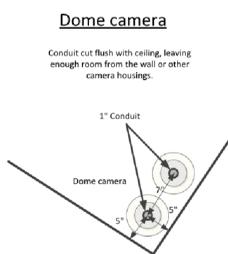


**5 ROOMS 109-110 CAMERA CONDUIT DETAIL**  
SCALE: NTS

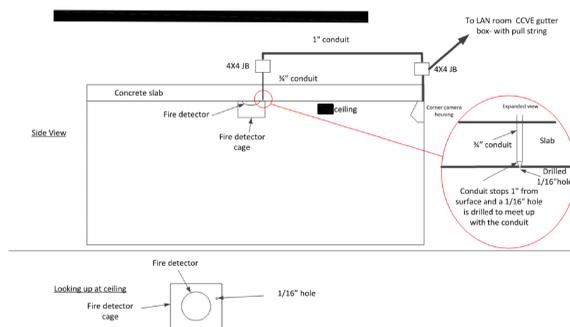


**6 ROOMS 150-170 SMOKE DETECTOR TYPICAL DETAILS**  
SCALE: NTS

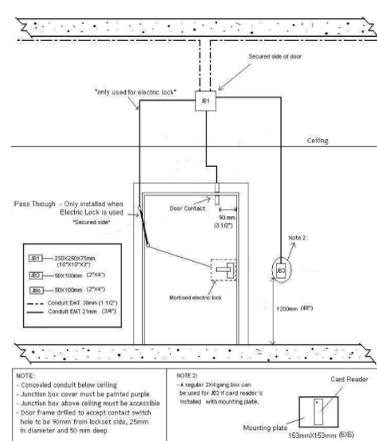

**7 DOOR ACCESS DETAIL**  
SCALE: NTS

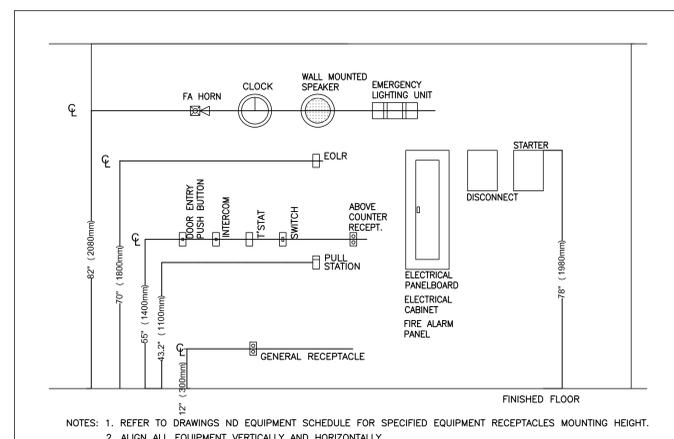

**8 TYPICAL MOUNTING HEIGHTS**  
SCALE: NTS

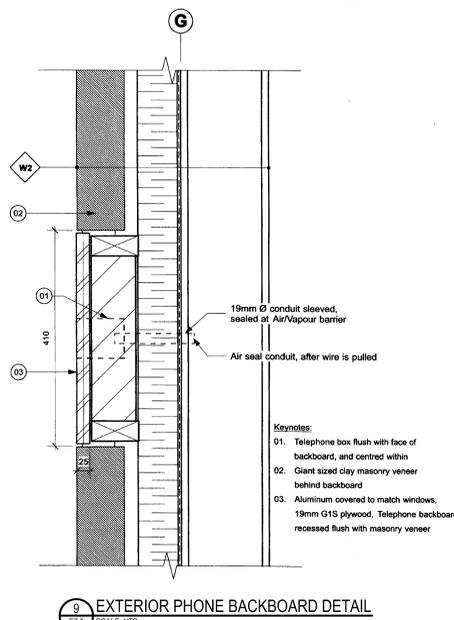

**9 EXTERIOR PHONE BACKBOARD DETAIL**  
SCALE: NTS

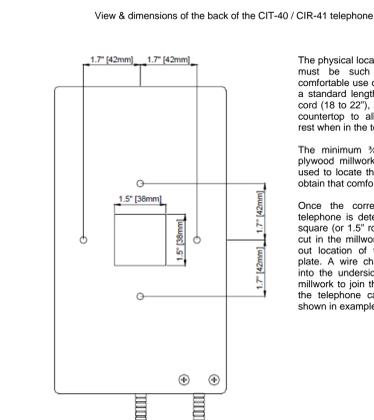


Figure 2 - Physical Dimensions of Back Plate

**10 CIT40 PHONE BACKBOARD DETAIL**  
SCALE: NTS

- Notes:
- CARD READER JUNCTION BOX SHALL BE INSTALLED ON THE SECURE SIDE OF THE DOOR AND LOCATED WITHIN 3.048m (10') FROM THE CARD READER.
  - ALL CARD ACCESS COMPONENTS/DEVICES WILL BE SUPPLIED, INSTALLED AND PROGRAMMED BY OTHERS. ELECTRICAL CONTRACTOR TO PROVIDE CONDUITS, PULL STRINGS, JUNCTION BOXES ROUGH-IN ONLY.

PERMIT TO PRACTICE  
WILLIAMS ENGINEERING INC.  
PERMIT NUMBER  
P 10527  
The Association of Prof. Engineers  
and Geoscientists of Alberta.

EDMONTON OFFICE  
Suite 620  
1000-102 Street  
Edmonton, AB T5A 3B1  
Tel: (780) 464-2293  
Fax: (780) 464-2393  
Info@williamsengineering.com  
www.williamsengineering.com

WILLIAMS  
ENGINEERING  
INC.

**WE**

Issues/Revisions

No.	Description	Date	By
A	ISSUED FOR 65% REVIEW	2018.05.15	BR
B	ISSUED FOR 75% REVIEW	2018.06.26	BR
C	ISSUED FOR 90% REVIEW	2018.09.27	BR
D	ISSUED FOR TENDER	2019.01.09	BR



Client: Government of Canada / Gouvernement du Canada

**Canada**

Project: **COALDALE PROTECTIVE SERVICES BUILDING**

Scale	AS NOTED	Designed By	BR
Project No.	0000	Drawn By	BR
Date	2001 JANUARY 00	Checked By	MF

Drawing Title: **ELECTRICAL DETAILS**

Drawing No.

**E7.0**