

CFIA Main Building 201 Replacement of Main Fire Pump

3851 Fallowfield Rd, Nepean



1
A0 LOCATION PLAN NTS

CONSTRUCTION ASSEMBLIES

	A0	ULC Des W453 2 H FRR	2 LAYERS 15.9 MM TYPE C GYPSUM BOARD EACH SIDE 64 MM 0.5 MM STEEL STUDS @ 610 MM O/C. JOINTS FINISHED
--	----	-------------------------	---

DRAWING LIST

A0	COVER SHEET
A1	DEMOLITION PLAN
A2	NEW CONSTRUCTION PLAN
A3	NEW CONSTRUCTION DETAILS, DOOR FRAME SCHEDULE

LEGEND

APPLICABLE TO ALL ARCHITECTURAL DRAWINGS

REFERENCE SYMBOLS

	BUILDING SECTION REFERENCE
	DETAIL NUMBER
	SECTION DETAIL REFERENCE
	DRAWING NUMBER
	DETAIL REFERENCE
	ELEVATION HEIGHT

LINE TYPES

	2 HOUR FIRE RESISTANCE RATING
--	-------------------------------

ABBREVIATIONS & SYMBOLS

APPLICABLE TO ALL ARCHITECTURAL DRAWINGS

±	APPROXIMATE
Ø	DIAMETER
A/B	AIR-BARRIER
ABV	ABOVE
AFF	ABOVE FINISHED FLOOR
B/O	BOTTOM OF
CL	CENTER LINE
CLEAR.	CLEARANCE
CONT.	CONTINUOUS
C/W	COMPLETE WITH
DEMO.	DEMOLITION
DWG	DRAWING
EXIST.	EXISTING
EQ.	EQUAL
EXT	EXTERIOR
GB	GYPSUM BOARD
INT	INTERIOR
MIRR	MIRRORED
MM	MILLIMETERS
MTL	METAL
N.I.C.	NOT IN CONTRACT
NTS	NOT TO SCALE
O/A	OVERALL
O/C	ON CENTER
O/H	OVERHEAD
PT	PAINT
REV	REVERSE
SIM	SIMILAR
T.B.D.	TO BE DETERMINED (ON SITE)
T/O	TOP OF
TYP	TYPICAL
U.N.O.	UNLESS NOTED OTHERWISE
U/S	UNDERSIDE

GENERAL NOTES FOR ALL DRAWINGS

- PRIOR TO COMMENCEMENT OF WORK, NOTIFY DEPARTMENTAL REPRESENTATIVE AND CONSULTANTS OF ANY DISCREPANCIES NOTED IN THE CONTRACT DOCUMENTS.
- PRIOR TO COMMENCEMENT OF WORK, REVIEW SITE CONDITIONS AND VERIFY ALL DIMENSIONS. NOTIFY DEPARTMENTAL REPRESENTATIVE OF ANY DISCREPANCIES.
- DO NOT SCALE DRAWINGS.
- REFER TO CONSULTANTS DRAWINGS AS APPLICABLE, FOR ADDITIONAL INFORMATION AND SPECIFIC DISCIPLINE RELATED DESIGN MATTERS.
- ALL DIMENSIONS ARE INDICATED IN MILLIMETRES UNLESS OTHERWISE SPECIFIED.
- THE CONTRACT DOCUMENTS ARE COMPLEMENTARY, AND WHAT IS REQUIRED BY ANY ONE SHALL BE AS BINDING AS IF REQUIRED BY ALL.
- NEITHER THE ORGANIZATION OF THE SPECIFICATIONS NOR THE ARRANGEMENT OF DRAWINGS SHALL CONTROL THE CONTRACTOR IN DIVIDING THE WORK AMONG SUBCONTRACTORS AND SUPPLIERS.

3	ISSUED FOR TENDER R2	2021-03-05
2	ISSUED FOR 99% REVIEW	2020-12-14
1	ISSUED FOR 66% REVIEW	2020-11-10
no.	revision	date



north north

KWC ARCHITECTS INC.
383 Parkdale Avenue, Suite 201
Ottawa Ontario Canada K1Y 4R4
PHONE (613) 238-2117
FAX (613) 238-6595
E MAIL kw@kwc-arch.com

detail no.	1	detail no.
sheet no.	A1	feuille no.

project
project
**CFIA MAIN BUILDING 201
REPLACEMENT OF MAIN FIRE
PUMP**

3851 FALLOWFIELD RD, NEPEAN, ON

designed by conçu par	KK	approved by approuvé par	MM
drawn by dessiné par	EI	project no. no. du projet	2078
date	09 NOVEMBER 2020	scale	as noted
drawing / dessin			


COVER SHEET
DRAWING LIST
ABBREVIATIONS & LEGEND
SPECIFICATIONS

revision
révision

sheet no. no. de la feuille	A0
--------------------------------	-----------

plot scale 1:1

plot scale 1:1

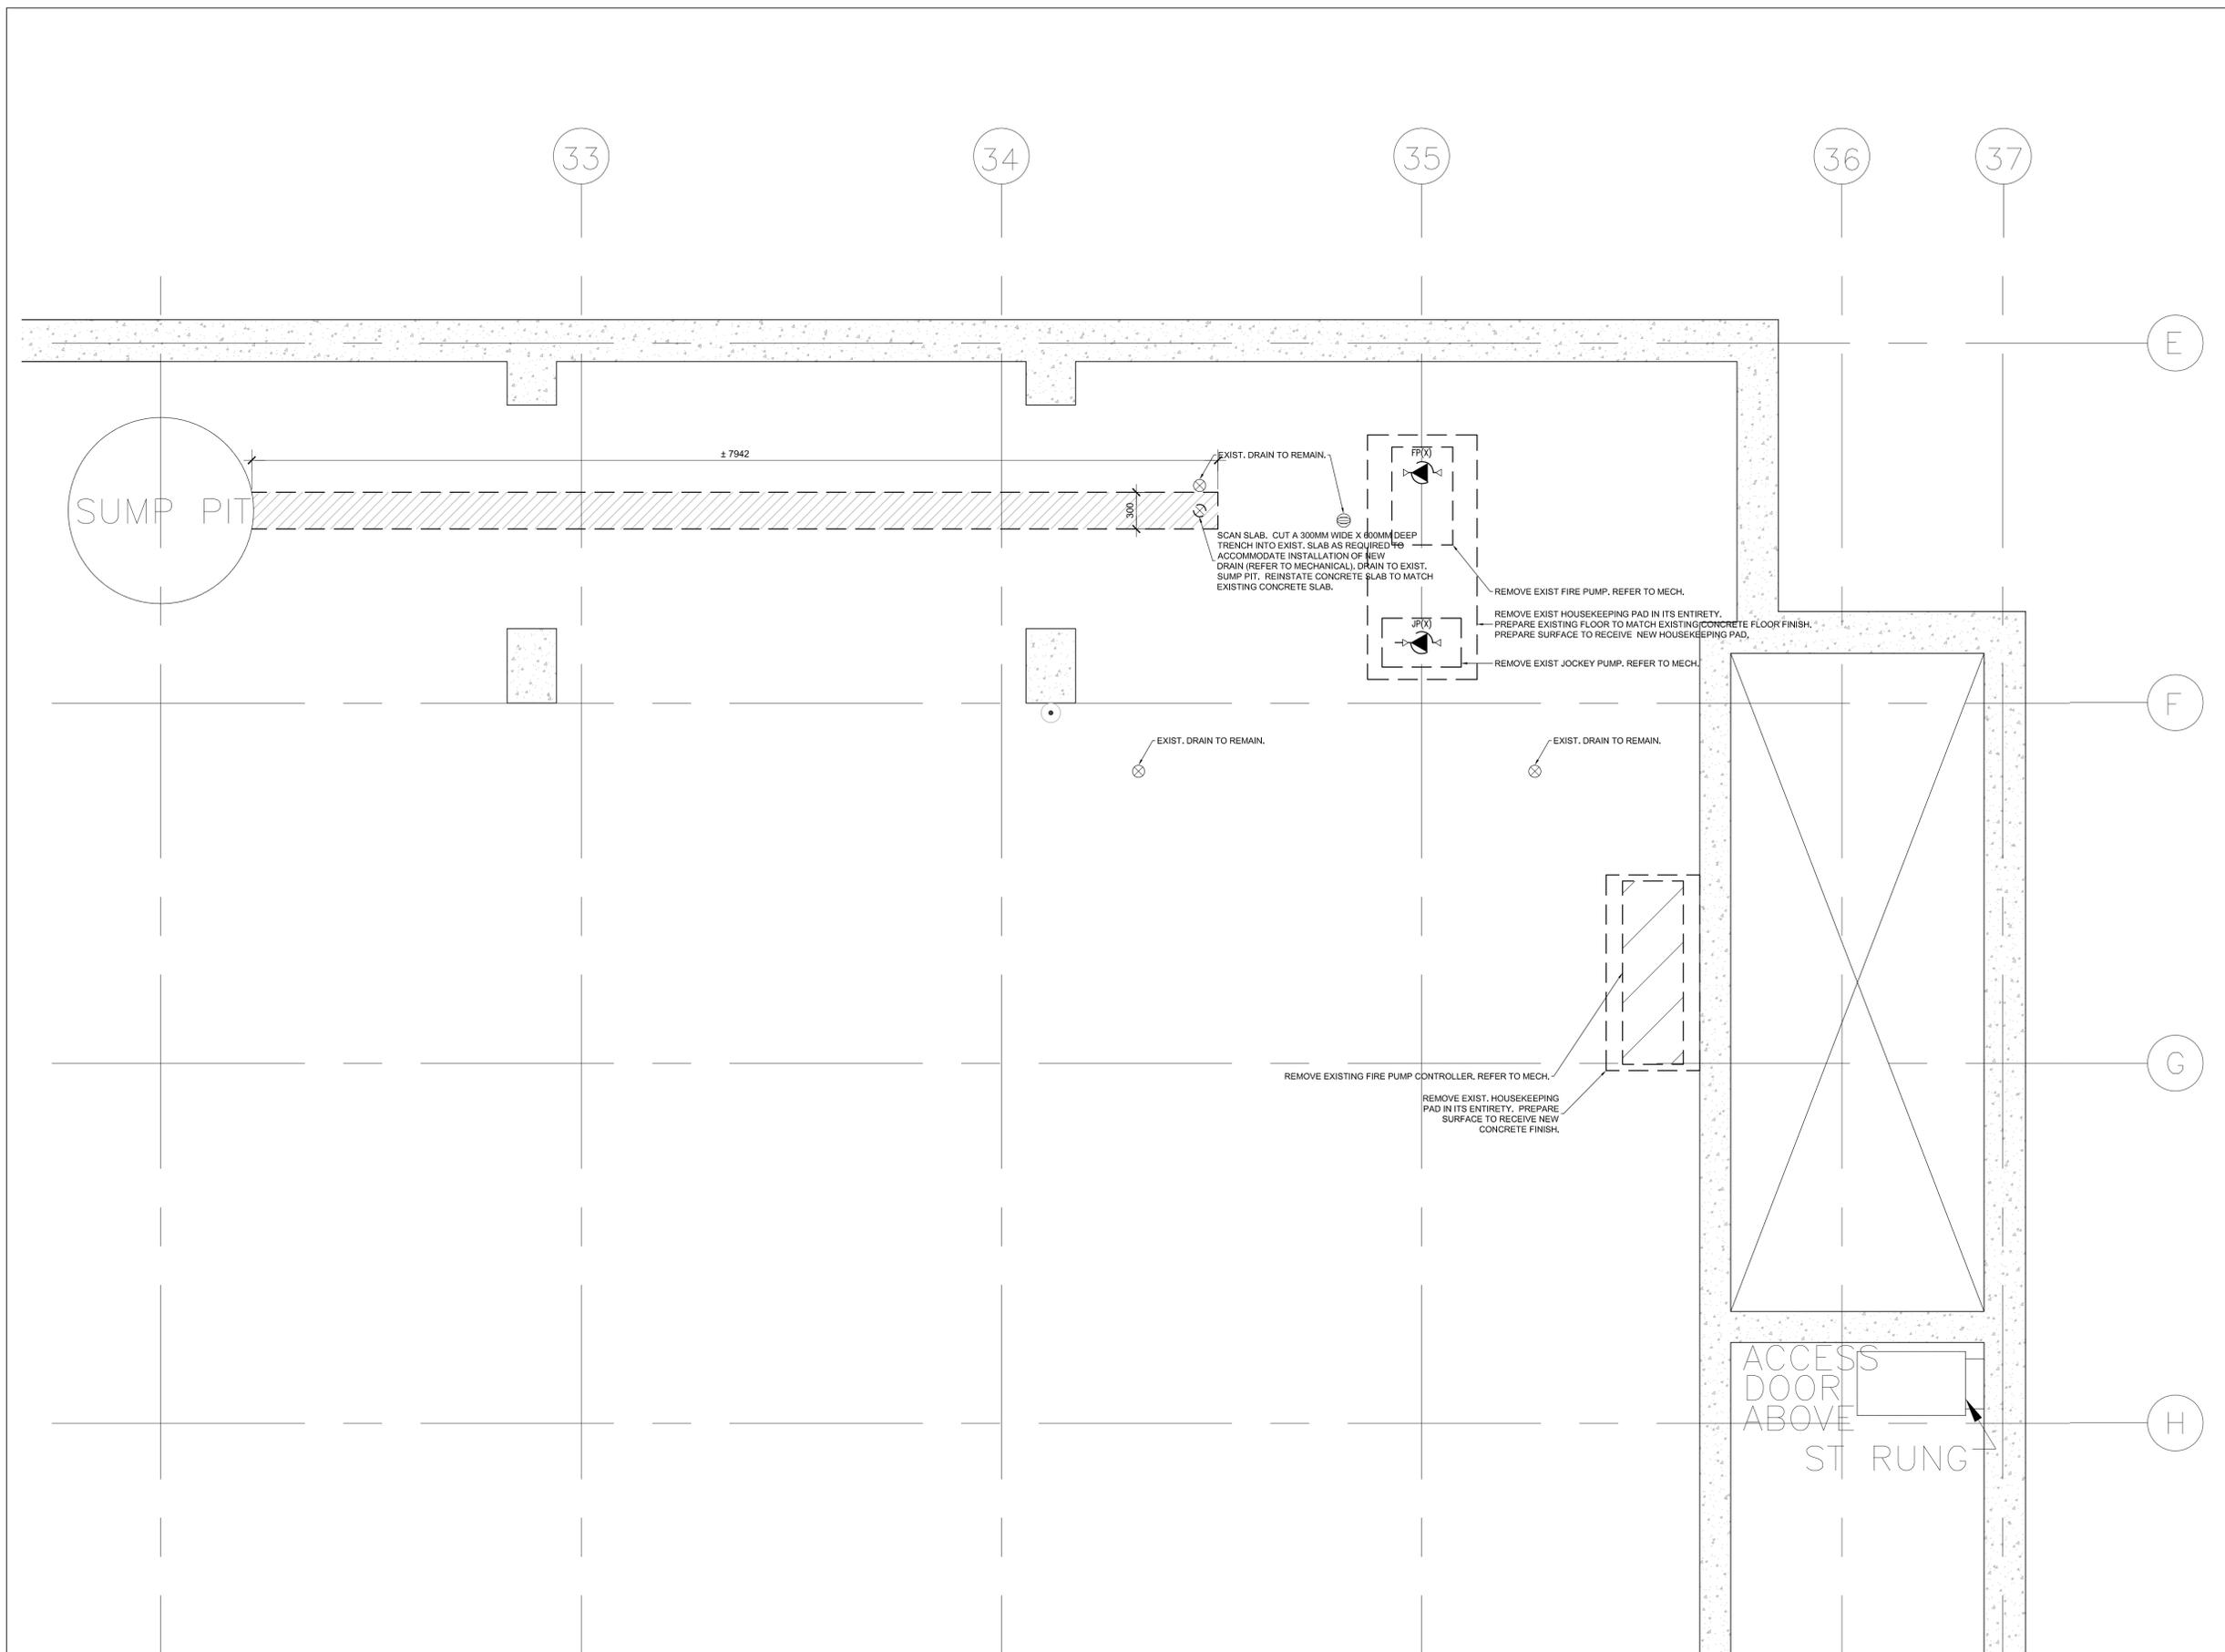


1
A1 DEMOLITION PLAN

scale 1 : 25

GENERAL NOTES FOR ALL DRAWINGS

- A. PRIOR TO COMMENCEMENT OF WORK, NOTIFY DEPARTMENTAL REPRESENTATIVE AND CONSULTANTS OF ANY DISCREPANCIES NOTED IN THE CONTRACT DOCUMENTS.
- B. PRIOR TO COMMENCEMENT OF WORK, REVIEW SITE CONDITIONS AND VERIFY ALL DIMENSIONS. NOTIFY DEPARTMENTAL REPRESENTATIVE OF ANY DISCREPANCIES.
- C. DO NOT SCALE DRAWINGS.
- D. REFER TO CONSULTANTS DRAWINGS AS APPLICABLE, FOR ADDITIONAL INFORMATION AND SPECIFIC DISCIPLINE RELATED DESIGN MATTERS.
- E. ALL DIMENSIONS ARE INDICATED IN MILLIMETRES UNLESS OTHERWISE SPECIFIED.
- F. THE CONTRACT DOCUMENTS ARE COMPLEMENTARY, AND WHAT IS REQUIRED BY ANY ONE SHALL BE AS BINDING AS IF REQUIRED BY ALL.
- G. NEITHER THE ORGANIZATION OF THE SPECIFICATIONS NOR THE ARRANGEMENT OF DRAWINGS SHALL CONTROL THE CONTRACTOR IN DIVIDING THE WORK AMONG SUBCONTRACTORS AND SUPPLIERS.

3	ISSUED FOR TENDER R2	2021-03-05
2	ISSUED FOR 99% REVIEW	2020-12-14
1	ISSUED FOR 66% REVIEW	2020-11-10
no.	revision	date

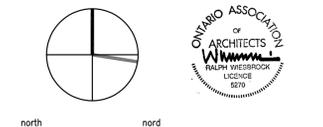

KWC ARCHITECTS INC.
 383 Parkdale Avenue, Suite 201
 Ottawa Ontario Canada K1Y 4R4
 PHONE (613) 238-2117
 FAX (613) 238-6595
 E MAIL kwc@kwc-arch.com

detail no. 1
 sheet no. A1

project
 projet
**CFIA MAIN BUILDING 201
 REPLACEMENT OF MAIN FIRE
 PUMP**


3851 FALLOWFIELD RD, NEPEAN, ON

designed by / conçu par KK approved by / approuvé par MM
 drawn by / dessiné par EI project no. / no. du projet 2078
 date 09 NOVEMBER 2020 scale as noted

drawing / dessin DEMOLITION PLAN

revision / révision sheet no. / no. de la feuille **A1**

plot scale 1:1

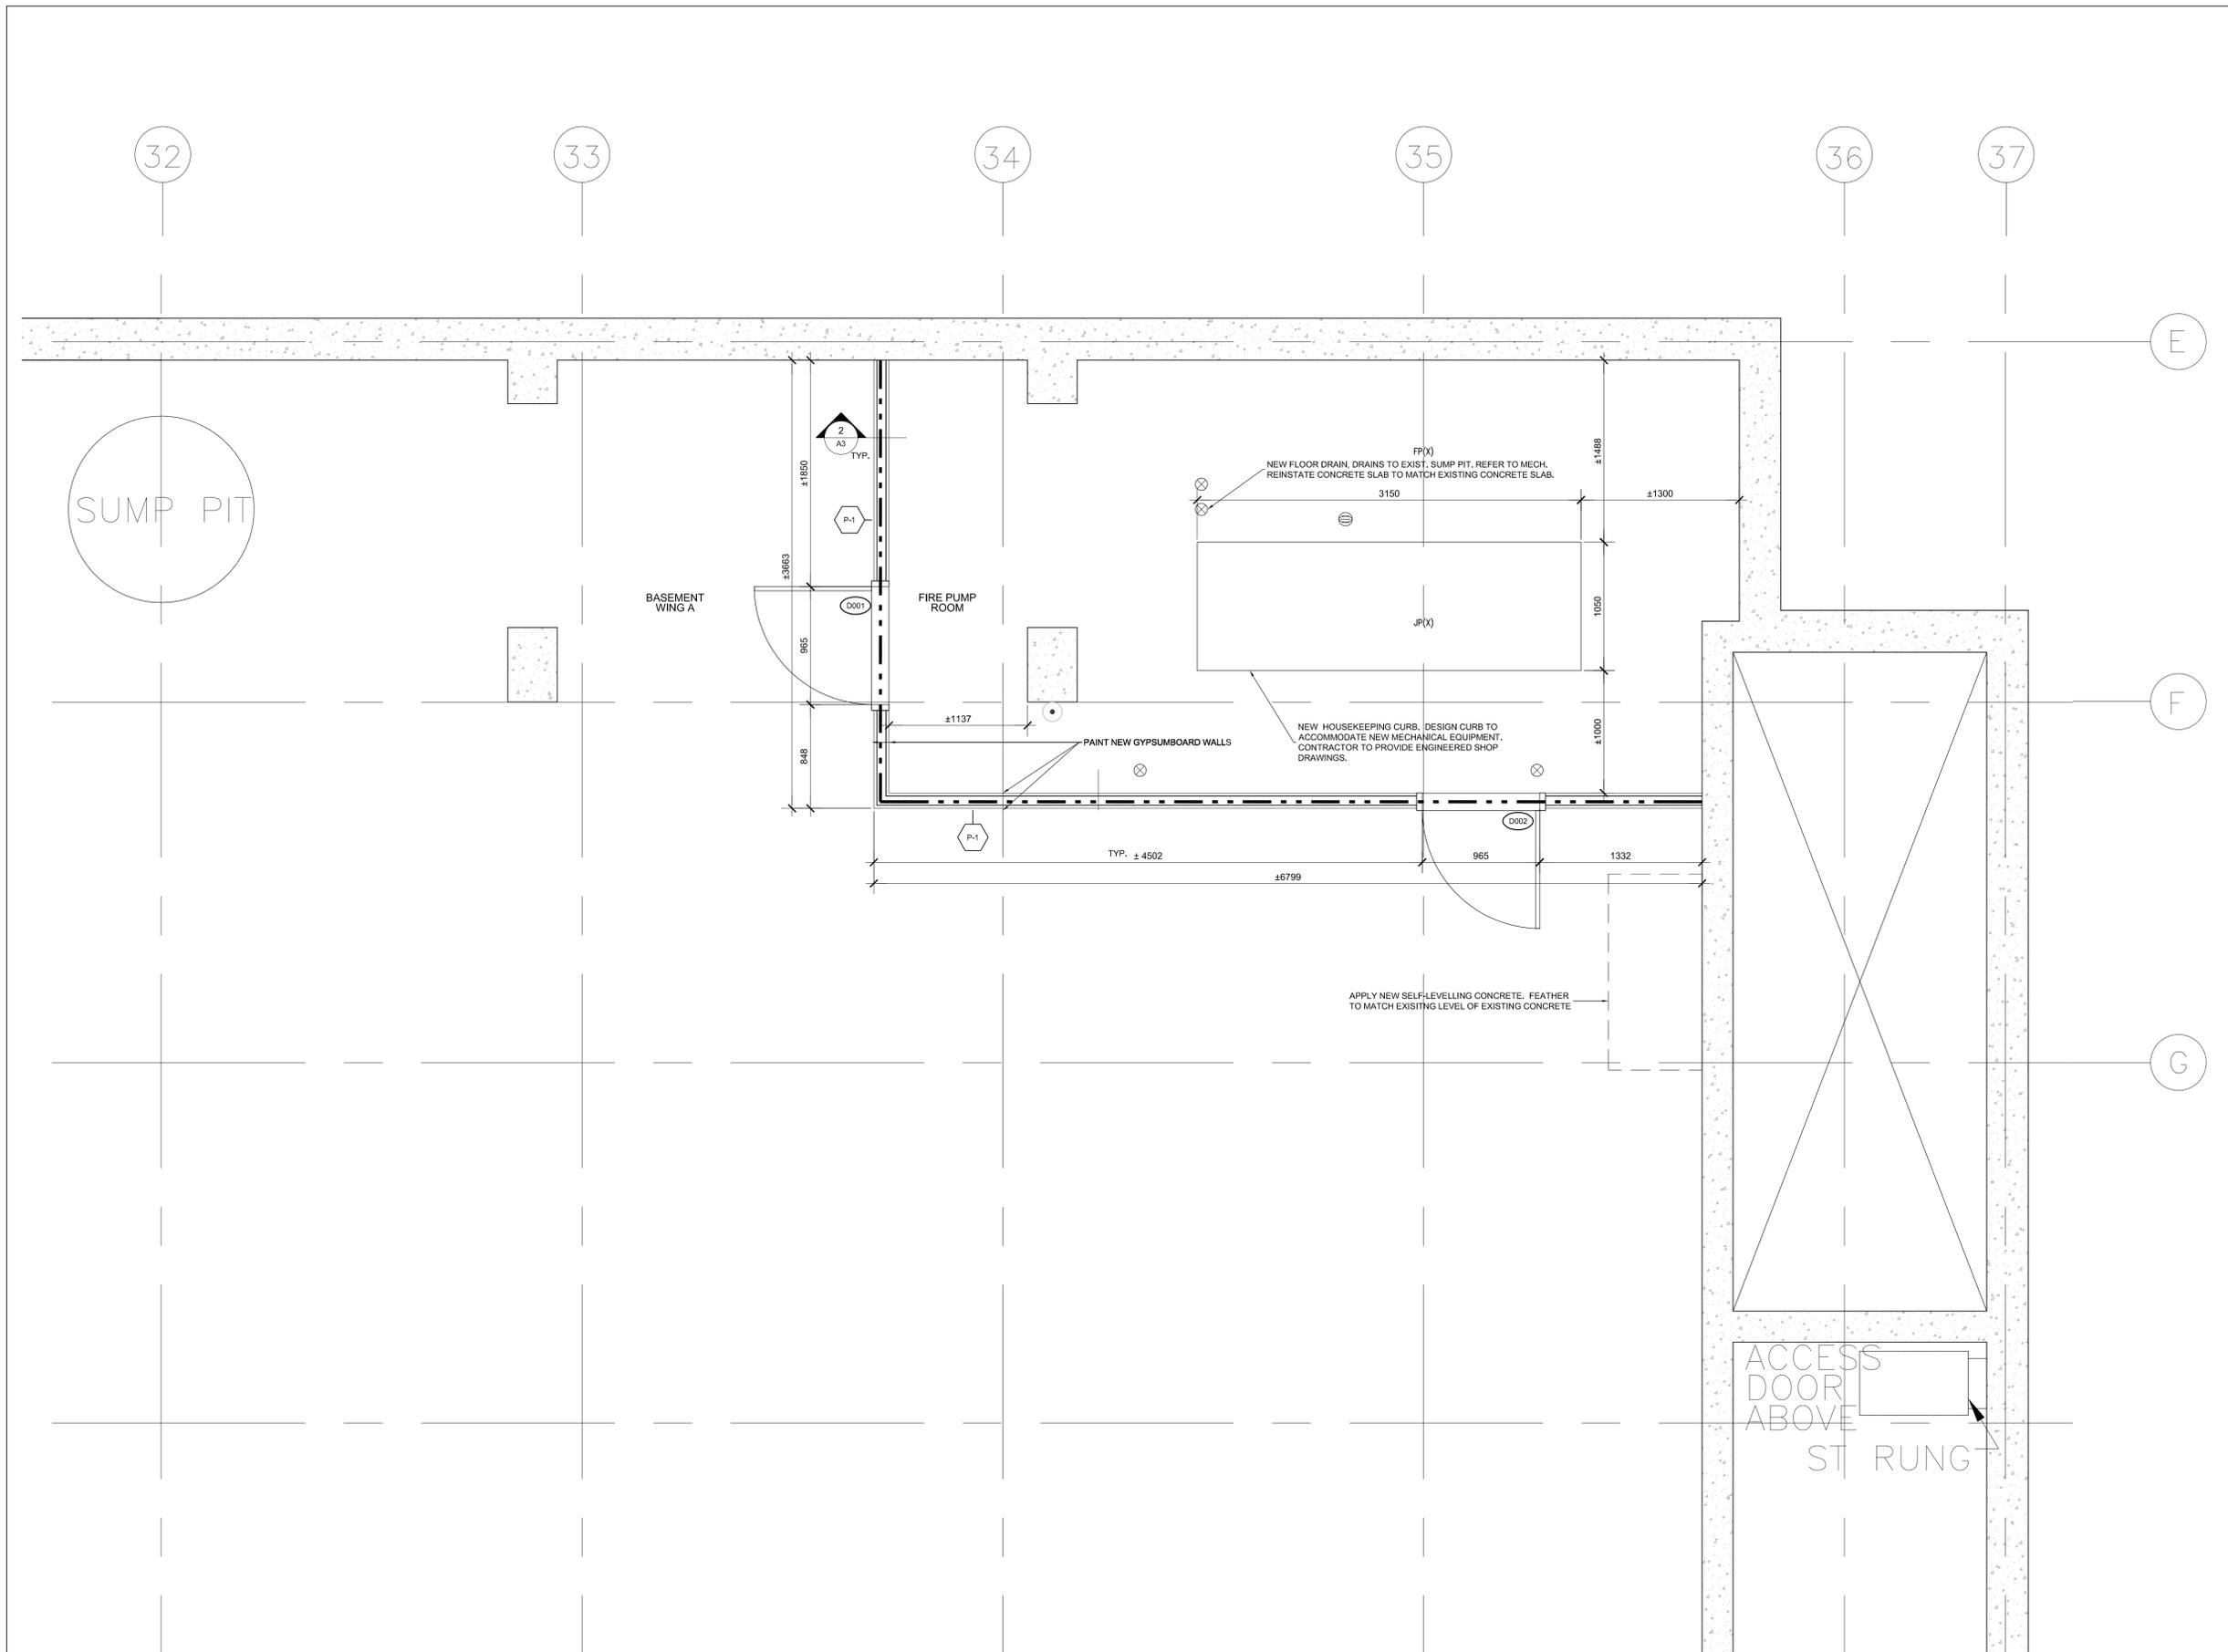


GENERAL NOTES FOR ALL DRAWINGS

- A. PRIOR TO COMMENCEMENT OF WORK, NOTIFY DEPARTMENTAL REPRESENTATIVE AND CONSULTANTS OF ANY DISCREPANCIES NOTED IN THE CONTRACT DOCUMENTS.
- B. PRIOR TO COMMENCEMENT OF WORK, REVIEW SITE CONDITIONS AND VERIFY ALL DIMENSIONS. NOTIFY DEPARTMENTAL REPRESENTATIVE OF ANY DISCREPANCIES.
- C. DO NOT SCALE DRAWINGS.
- D. REFER TO CONSULTANTS DRAWINGS AS APPLICABLE, FOR ADDITIONAL INFORMATION AND SPECIFIC DISCIPLINE RELATED DESIGN MATTERS.
- E. ALL DIMENSIONS ARE INDICATED IN MILLIMETRES UNLESS OTHERWISE SPECIFIED.
- F. THE CONTRACT DOCUMENTS ARE COMPLEMENTARY, AND WHAT IS REQUIRED BY ANY ONE SHALL BE AS BINDING AS IF REQUIRED BY ALL.
- G. NEITHER THE ORGANIZATION OF THE SPECIFICATIONS NOR THE ARRANGEMENT OF DRAWINGS SHALL CONTROL THE CONTRACTOR IN DIVIDING THE WORK AMONG SUBCONTRACTORS AND SUPPLIERS.

LEGEND

--- 2H F.R.R.

3	ISSUED FOR TENDER R2	2021-03-05
2	ISSUED FOR 99% REVIEW	2020-12-14
1	ISSUED FOR 66% REVIEW	2020-11-10
no.	revision	date

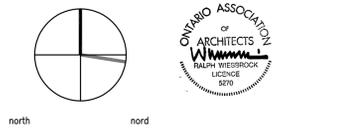

KWC ARCHITECTS INC.
 383 Parkdale Avenue, Suite 201
 Ottawa Ontario Canada K1Y 4R4
 PHONE (613) 238-2117
 FAX (613) 238-6595
 E MAIL kwc@kwc-arch.com

detail no. 1 detail no.
 sheet no. A1 feuille no.

project
 projet
**CFIA MAIN BUILDING 201
 REPLACEMENT OF MAIN FIRE
 PUMP**

3851 FALLOWFIELD RD, NEPEAN, ON

designed by / conçu par KK approved by / approuvé par MM
 drawn by / dessiné par EI project no. / no. du projet 2078
 date 09 NOVEMBER 2020 scale as noted


drawing / dessin
NEW CONSTRUCTION PLAN

1
A2 **NEW CONSTRUCTION PLAN** scale 1:25

DOOR AND FRAME SCHEDULE


ROOM NO.	DOOR						GLAZ'G	FRAME		NOTES
	DOOR FROM (F) / TO (T)	WIDTH	HEIGHT	THICKN.	MAT.	FIN.	MAT.	MAT.	FIN.	
Fire Pump Room	D001 (F)	915	2135	50	HM	PT	NONE	HM	PT	INSTALL MORTISE LOCK AND LATCH - COORDINATE WITH BUILDING MASTER KEY SYSTEM NEW 2 HR FIRE RATED DOOR AND FRAME
Fire Pump Room	D002 (F)	915	2135	50	HM	PT	NONE	HM	PT	INSTALL MORTISE LOCK AND LATCH - COORDINATE WITH BUILDING MASTER KEY SYSTEM NEW 2 HR FIRE RATED DOOR AND FRAME

1. ALL HARDWARE TO BE INSTALLED AT MIN. 864MM AND 1219MM MAX ABOVE FINISHED FLOOR.

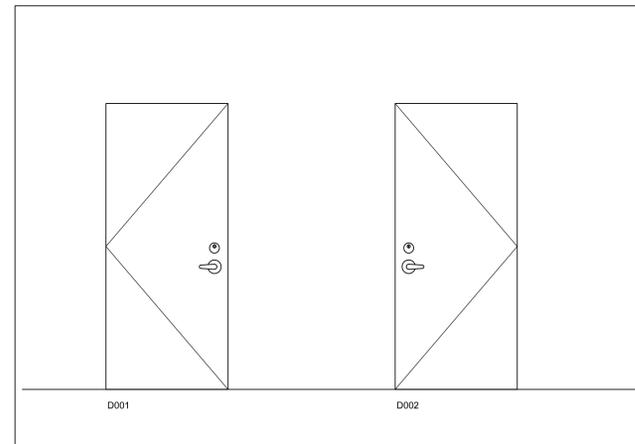


1
A3 DOOR ELEVATIONS

scale 1 : 25

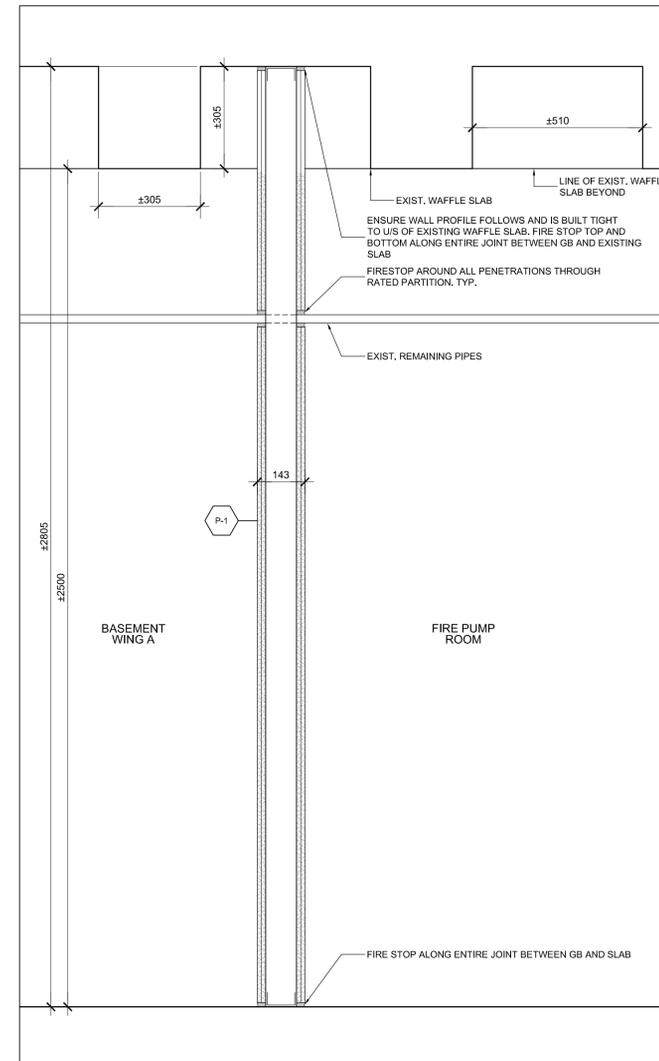

2
A3 WALL SECTION @ NEW PARTITION

scale 1 : 10

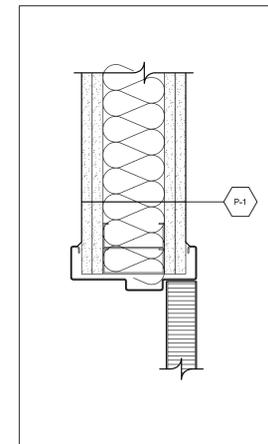

3
A3 FRAME DETAIL

scale 1 : 5


GENERAL NOTES FOR ALL DRAWINGS

- A. PRIOR TO COMMENCEMENT OF WORK, NOTIFY DEPARTMENTAL REPRESENTATIVE AND CONSULTANTS OF ANY DISCREPANCIES NOTED IN THE CONTRACT DOCUMENTS.
- B. PRIOR TO COMMENCEMENT OF WORK, REVIEW SITE CONDITIONS AND VERIFY ALL DIMENSIONS. NOTIFY DEPARTMENTAL REPRESENTATIVE OF ANY DISCREPANCIES.
- C. DO NOT SCALE DRAWINGS.
- D. REFER TO CONSULTANTS DRAWINGS AS APPLICABLE, FOR ADDITIONAL INFORMATION AND SPECIFIC DISCIPLINE RELATED DESIGN MATTERS.
- E. ALL DIMENSIONS ARE INDICATED IN MILLIMETRES UNLESS OTHERWISE SPECIFIED.
- F. THE CONTRACT DOCUMENTS ARE COMPLEMENTARY, AND WHAT IS REQUIRED BY ANY ONE SHALL BE AS BINDING AS IF REQUIRED BY ALL.
- G. NEITHER THE ORGANIZATION OF THE SPECIFICATIONS NOR THE ARRANGEMENT OF DRAWINGS SHALL CONTROL THE CONTRACTOR IN DIVIDING THE WORK AMONG SUBCONTRACTORS AND SUPPLIERS.

LEGEND

----- 2H F.R.R.

no.	revision	date
3	ISSUED FOR TENDER R2	2021-03-05
2	ISSUED FOR 99% REVIEW	2020-12-14
1	ISSUED FOR 66% REVIEW	2020-11-10

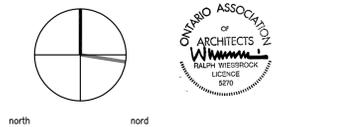

KWC ARCHITECTS INC.
 383 Parkdale Avenue, Suite 201
 Ottawa Ontario Canada K1Y 4R4
 PHONE (613) 238-2117
 FAX (613) 238-6595
 E MAIL kwc@kwc-arch.com

detail no. 1 detail no.
 sheet no. A1 feuille no.

project
 projet
**CFIA MAIN BUILDING 201
 REPLACEMENT OF MAIN FIRE
 PUMP**

3851 FALLOWFIELD RD, NEPEAN, ON

designed by / conçu par KK approved by / approuvé par MM
 drawn by / dessiné par EI project no. / no. du projet 2078
 date 09 NOVEMBER 2020 scale as noted

drawing / dessin
**NEW CONSTRUCTION DETAILS
 DOOR FRAME SCHEDULE**

plot scale 1:1